


## Location of Proposed Project

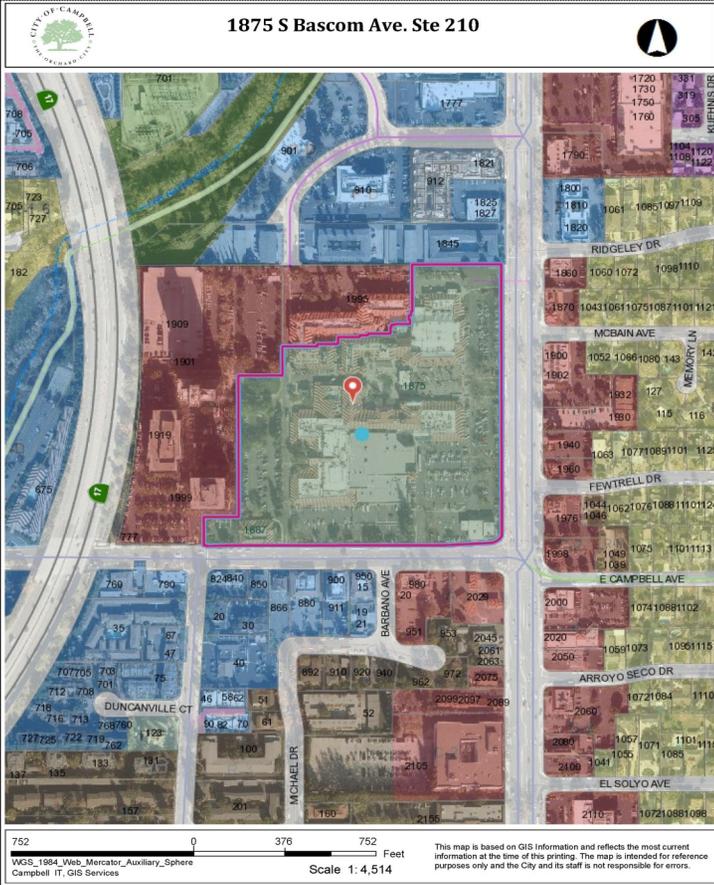


 City of Campbell  
 70 North First Street  
 Campbell, CA 95008 –1423

## Project Image



# Courtesy Notice

Dear Campbell Resident,

November 30, 2022

We are notifying you that the Planning Division of the Community Development Department of the City of Campbell has received an application for the following project:

**Project Address:** 1875 S. Bascom Ave., Ste. 210  
**Zoning | Area Plan:** C-2-O | Pruneyard Master Use Permit  
**Neighborhood Association(s):** N/A  
**File No.:** PLN-2022-155  
**APN:** 288-04-028  
**Applicant:** Scott Daves  
**Property Owner:** Pruneyard Regency LLC  
**Application Type:** Architectural Modification

## Project Description:

Exterior façade improvements to Pruneyard building 'R5,' to accommodate a new tenant, the Shade Store, and a change to a "specialty sign" placement.

**Project Planner:** Daniel Fama, Senior Planner  
**Email Contact:** danielf@campbellca.gov  
**Phone Contact:** (408) 866-2193

If you would like to find out more information regarding the proposed project, please view the project plans using the QR code below or contact the Project Planner. The City will send you another notice before the City makes a decision regarding approval of the project.

Before a decision is reached you will receive a formal notice providing another opportunity for public comment.



- City of Campbell -  
Community Development Department  
70 N. First Street, Campbell CA 95008  
(408)866-2140 | [planning@campbellca.gov](mailto:planning@campbellca.gov)

**Note:** Applications may change after initial application submittal. To view the project plans, please scan the QR code.

\*\*Asistencia en Español disponible,  
Simplemente marque (408) 866-2140 y pida traducción en Español





ARCHITECT OF RECORD:  
 MATTHEW REISKIN  
 6200 LENOX ROAD  
 BETHESDA, MD 20817  
 PH: 240-205-0762  
 CHANEISKIN@YAHOO.COM

SEAL:  
 ARCHITECT: MATTHEW REISKIN, I  
 HEREBY CERTIFY THAT THIS  
 DRAWING WAS PREPARED BY ME  
 OR UNDER MY DIRECT  
 SUPERVISION AND THAT I AM A  
 DULY REGISTERED/LICENSED  
 ARCHITECT UNDER THE LAWS OF  
 THE STATE OF CALIFORNIA

CA ARCHITECTURAL REG. No: C30220

11/17/2022	ARCHITECTURAL MODIFICATION PERMIT SUBMITTAL
11/11/2022	LL REVIEW SET



THE  
 SHADE  
 STORE

PROJECT LOCATION  
 THE SHADE STORE  
 1875 S BASCOM AVE,  
 CAMPBELL, CA 95008

SPACE NO. OP2B

AREA:

SHEET TITLE:

SITE PLAN

PROJECT NO. 22-028


SCALE: AS NOTED

DRAWN BY: AM

REVIEWED BY: MR

SHEET NO:

CS-102

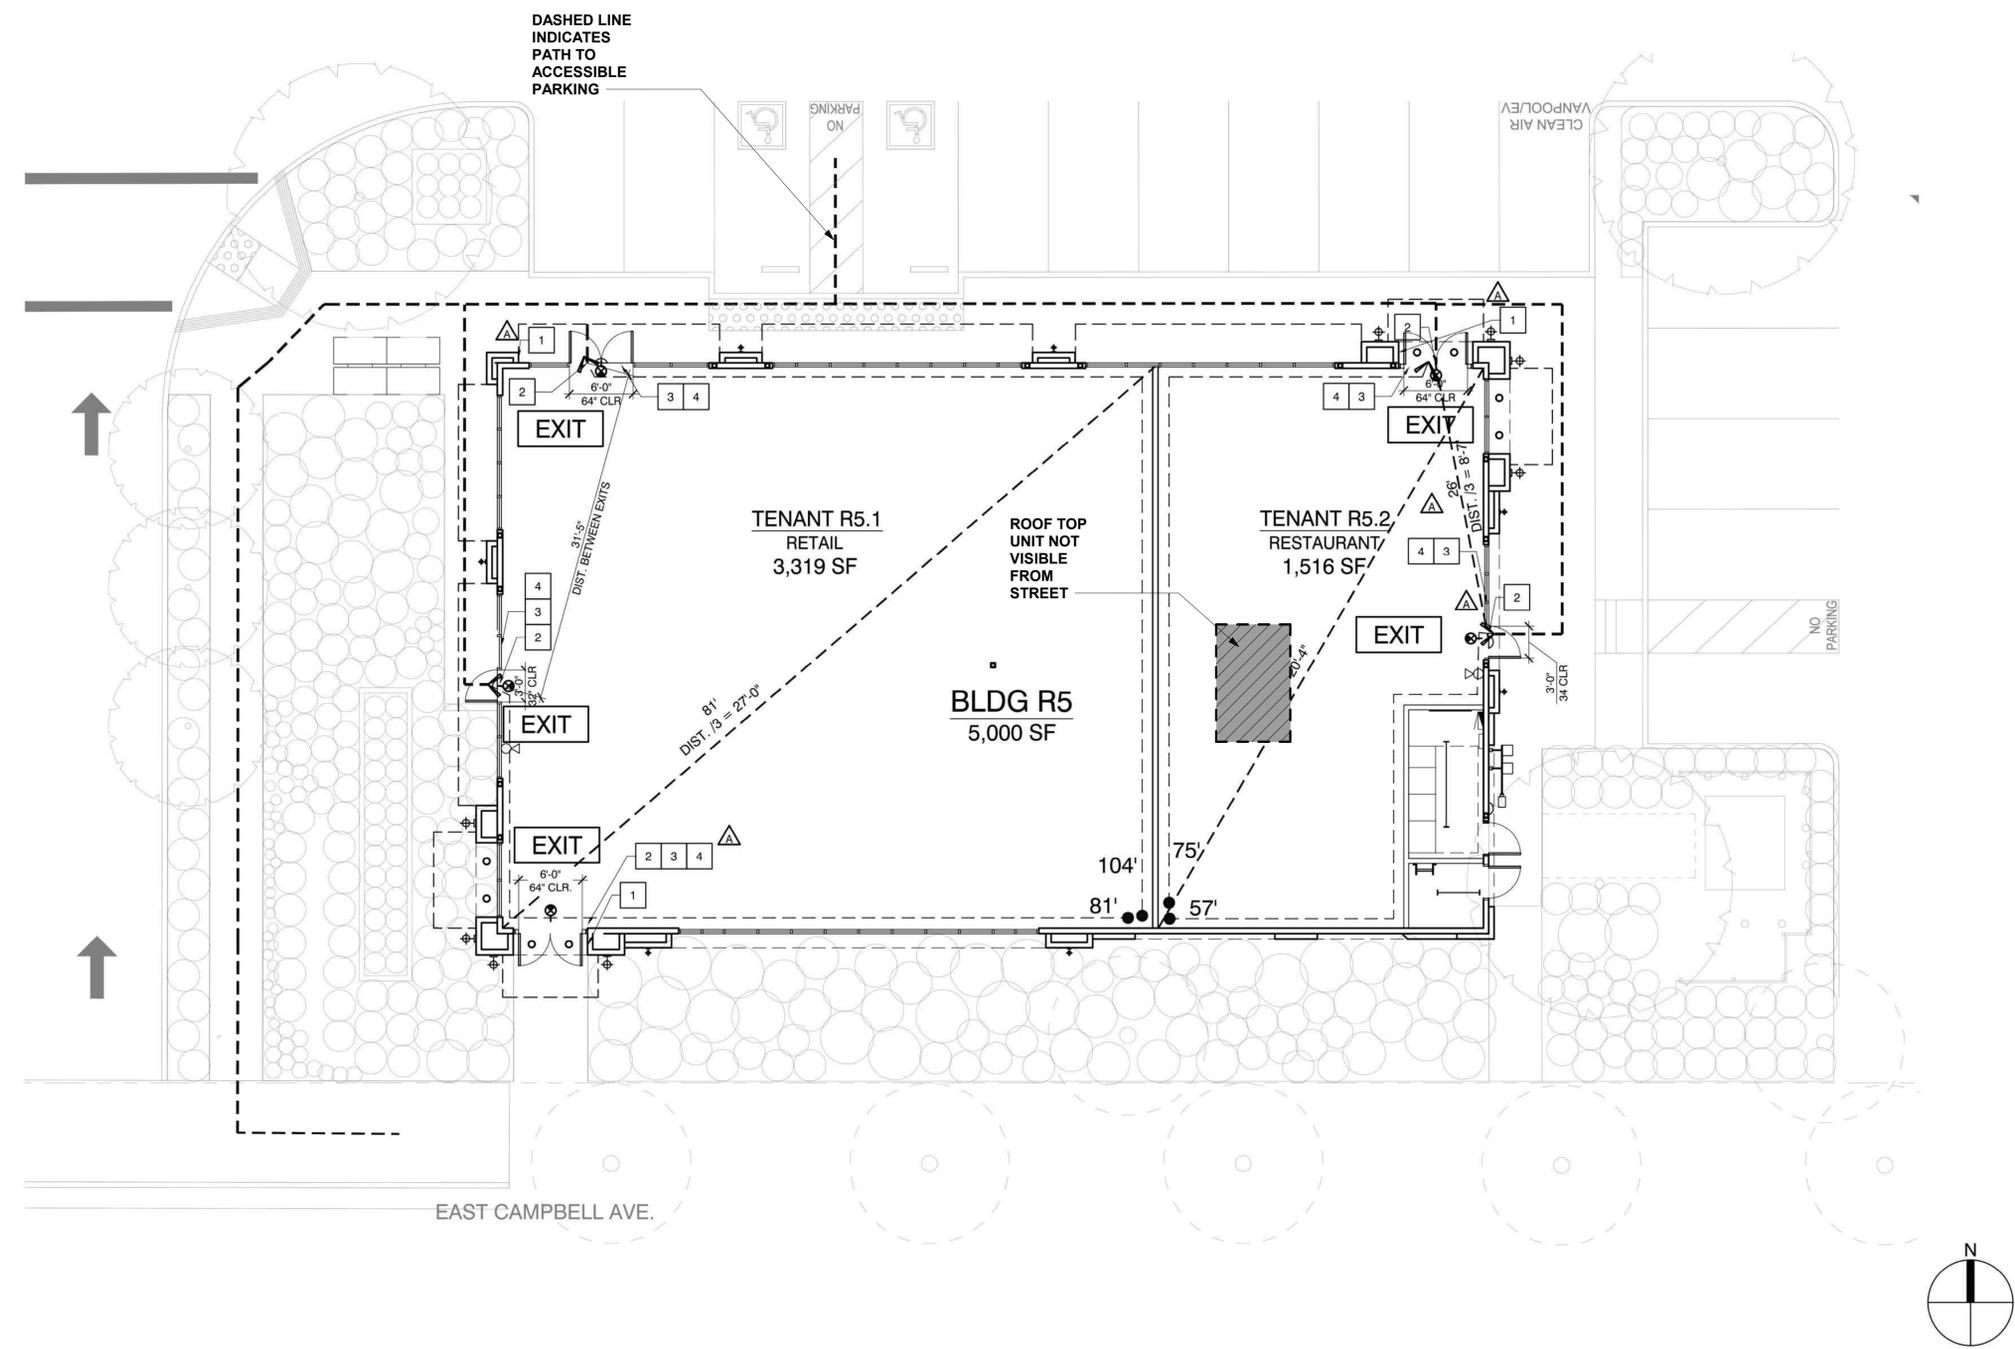

NOTE:  
 SITE PLAN  
 PROVIDED BY  
 LANDLORD BASE  
 BUILD ARCH FOR  
 REFERENCE  
 PURPOSES ONLY

NOTE:  
 NO PROPOSED  
 CHANGE TO  
 NUMBER OF  
 PARKING SPACES  
 OR LAYOUT. ALL  
 ACCESSIBLE  
 PARKING EXISTING  
 TO REMAIN.


NOTE:  
 NO PROPOSED  
 WORK TO MODIFY  
 PARKING OR THE  
 SITE. IF AHJ FINDS  
 ANY CONDITIONS  
 ON SITE TO BE  
 INACCESSIBLE, IT  
 IS LANDLORDS  
 RESPONSIBILITY  
 TO ADDRESS.

1 SITE  
 N.T.S.








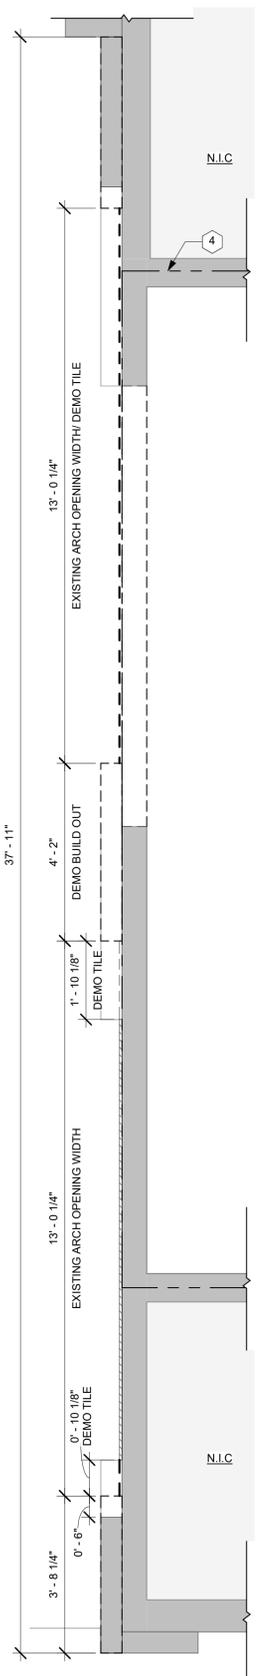

1 EXISTING CONDITIONS/DEMOLITION PLAN - Callout 1  
1/2" = 1'-0"

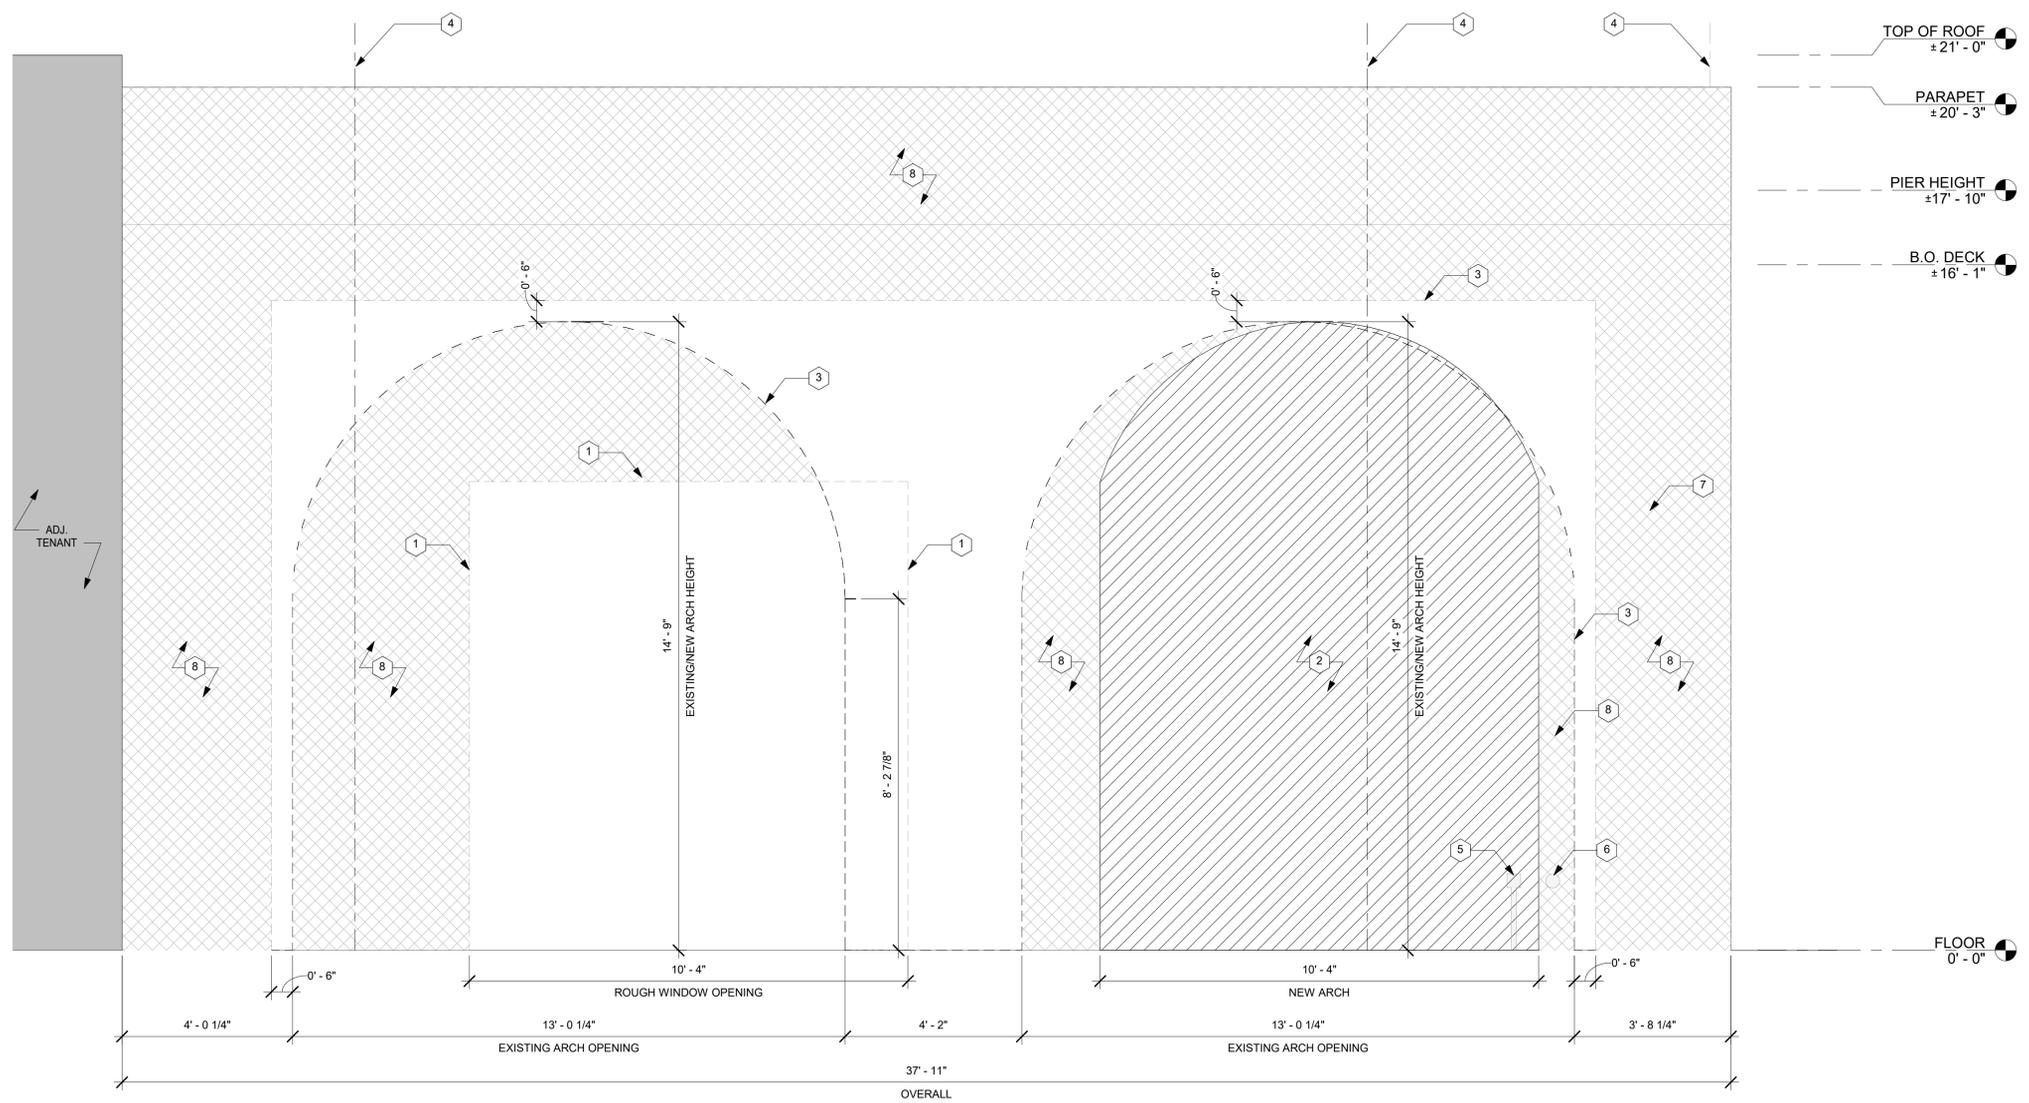

2 EXISTING CONDITIONS/DEMOLITION ELEVATION  
1/2" = 1'-0"

- TOP OF ROOF ±21' - 0"
- PARAPET ±20' - 3"
- PIER HEIGHT ±17' - 10"
- B.O. DECK ±16' - 1"
- FLOOR 0' - 0"

GENERAL DEMOLITION NOTES	
SYMBOL	NOTES
1	DASHED LINE INDICATED PORTION OF WALL TO BE DEMOLISHED FOR WINDOW OPENING
2	HATCH INDICATED EXISTING PORTION OF EXTERIOR FINISH TILE TO REMAIN.
3	EXTERIOR FACADE BUILD OUT TO BE DEMOLISHED
4	LEASELINE
5	EXISTING ELECTRICAL CONDUIT TO REMAIN. IF ANY MODIFICATIONS ARE REQUIRED, COORDINATE WITH THE LANDLORD AND UTILITY COMPANY BEFORE ANY WORK IS PERFORMED.
6	EXISTING FIRE SPRINKLER DRAIN TO REMAIN. IF ANY MODIFICATIONS ARE REQUIRED, COORDINATE WITH THE LANDLORD AND UTILITY COMPANY BEFORE ANY WORK IS PERFORMED.
7	IF REQUIRED, G.C. TO REMOVE AND REPLACE ORIENTATIONAL NUMBERS IF PORTION OF WALL IS NEEDED TO BE DEMOLISHED.
8	HATCH INDICATES PORTION OF EXTERIOR FACADE BUILDOUT TO REMAIN.
9	---
10	---

GENERAL DEMOLITION NOTES	
1.	ALL DOORS, WALLS, FIXTURES, ETC. SHOWN IN DASHED LINES ARE TO BE REMOVED AND DISPOSED OF UNLESS NOTED OTHERWISE.
2.	THE ARCHITECT IS TO BE NOTIFIED IMMEDIATELY OF ANY UNFORESEEN HAZARDS/CONDITIONS OF ANY KIND. ALL CONDITIONS AND DIMENSIONS ARE TO BE CHECKED FOR DISCREPANCIES AND THE ARCHITECT IS TO BE NOTIFIED. THERE MAY HAVE BEEN AREAS WHICH WERE NOT ACCESSIBLE AT THE TIME OF THE EXISTING CONDITIONS SITE VISIT AND MAY NEED FURTHER CONSIDERATION.
3.	NO ALTERATION TO THE EXISTING STRUCTURAL MEMBERS ARE ALLOWED.
4.	COORDINATE WITH THE LANDLORD OR REPRESENTATIVE FOR ANY AND ALL DEMOLITION REQUIREMENTS WHICH THEY MAY HAVE.
5.	FIRE SEPARATIONS BETWEEN TENANT SPACES ARE TO BE RETAINED DURING DEMOLITION AT ALL TIMES.
6.	THE GENERAL CONTRACTOR WILL RESTORE ANY DAMAGE DURING DEMOLITION TO THE ORIGINAL STATE BEFORE DEMOLITION STARTED.
7.	THE CONSTRUCTION SITE IS TO BE SEALED TIGHTLY AND ANY CONSTRUCTION BARRICADES SHALL BE REVIEWED WITH THE LANDLORD, PRIOR TO CONSTRUCTION.
8.	THE GENERAL CONTRACTOR SHALL COORDINATE WITH THE LANDLORD IF ANY RELOCATION OF EXISTING SERVICE LINES SUCH AS SPRINKLER MAIN, DOMESTIC WATER, SEWER LINE, GAS LINE ETC. IS REQUIRED TO ACCOMMODATE THE NEW WORK.
9.	THE ADJACENT TENANT PROPERTY IS TO BE MAINTAINED DURING DEMOLITION AND IF ANYTHING IS DAMAGED DURING THE WORK, IT IS TO BE REPAIRED OR REPLACED AT THE GENERAL CONTRACTORS COST. THIS INCLUDES PROPERTY WITHIN THE LEASE OUTLINE DIMENSIONS WHICH PASSED THROUGH THE SPACE.
10.	ANY ABANDONED SERVICES OR UTILITIES SHALL BE REMOVED TO THE SOURCE AFTER REVIEW WITH THE LANDLORD AND/OR LOCAL AUTHORITIES.
11.	HORN STROBES ARE PRESENT IN THE SPACE BUT THERE IS NO PULL STATION. ALL WORK FOR THE FIRE ALARM SYSTEM IS TO BE COORDINATED WITH THE LL REQUIRED VENDOR TO DETERMINE IF PULL STATIONS ARE REQUIRED.

DEMOLITION LEGEND	
SYMBOL	DESCRIPTION
	EXISTING PARTITION
	DEMOLITION PARTITION
	EXISTING DOOR
	EXISTING DOOR TO BE DEMOLISHED

ARCHITECT OF RECORD:  
 MATTHEW REISKIN  
 6200 LENOX ROAD  
 BETHESDA, MD 20817  
 PH: 240-205-0762  
 CHANEISKIN@YAHOO.COM

SEAL:  
 ARCHITECT: MATTHEW REISKIN, I  
 HEREBY CERTIFY THAT THIS  
 DRAWING WAS PREPARED BY ME  
 OR UNDER MY DIRECT  
 SUPERVISION AND THAT I AM A  
 DULY REGISTERED/LICENSED  
 ARCHITECT UNDER THE LAWS OF  
 THE STATE OF CALIFORNIA

CA ARCHITECTURAL REG. No: C30220

11/17/2022	ARCHITECTURAL MODIFICATION PERMIT SUBMITTAL
11/11/2022	LL REVIEW SET



THE SHADE STORE

PROJECT LOCATION  
 THE SHADE STORE  
 1875 S BASCOM AVE,  
 CAMPBELL, CA 95008

SPACE NO. OP2B

AREA:  
 SHEET TITLE:

DEMOLITION EXTERIOR WALL PLAN AND ELEVATION

PROJECT NO. 22-028


SCALE: AS NOTED

DRAWN BY: RB

REVIEWED BY: MR

SHEET NO:

A-104

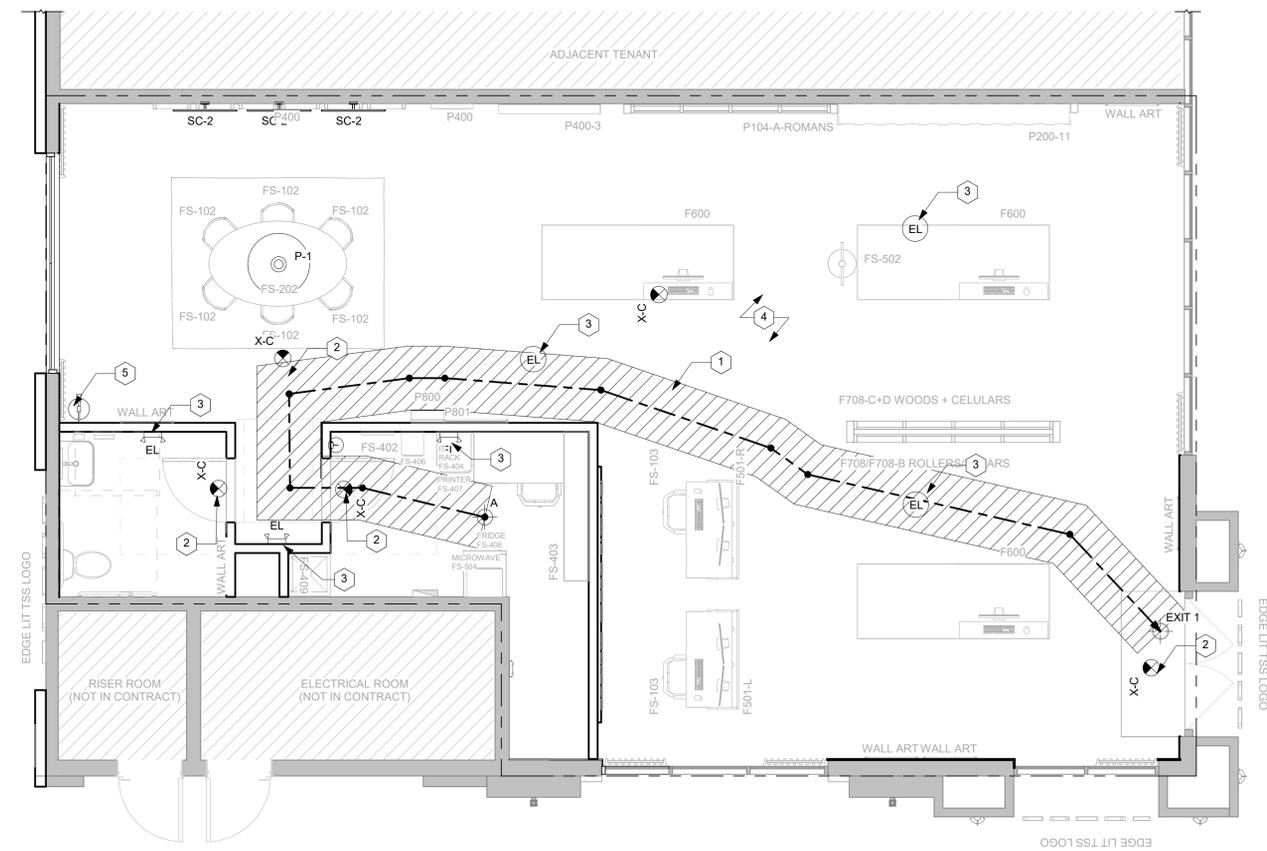

1 LIFE SAFETY PLAN  
1/4" = 1'-0"

ARCHITECT OF RECORD:  
MATTHEW REISKIN  
6200 LENOX ROAD  
BETHESDA, MD 20817  
PH: 240-205-0762  
CHANEISKIN@YAHOO.COM

SEAL:  
ARCHITECT: MATTHEW REISKIN, I  
HEREBY CERTIFY THAT THIS  
DRAWING WAS PREPARED BY ME  
OR UNDER MY DIRECT  
SUPERVISION AND THAT I AM A  
DULY REGISTERED/LICENSED  
ARCHITECT UNDER THE LAWS OF  
THE STATE OF CALIFORNIA

CA ARCHITECTURAL REG. No: C30220

11/17/2022	ARCHITECTURAL MODIFICATION PERMIT SUBMITTAL
11/11/2022	LL REVIEW SET



THE  
SHADE  
STORE

PROJECT LOCATION  
THE SHADE STORE  
1875 S BASCOM AVE,  
CAMPBELL, CA 95008

SPACE NO. OP2B

AREA:

SHEET TITLE:

LIFE SAFETY PLAN

PROJECT NO. 22-028

SCALE: AS NOTED

 
DRAWN BY: Author

REVIEWED BY: MR

SHEET NO:

A-111

EGRESS ANALYSIS



PER 1006.2.1  
MAX COMMON PATH OF TRAVEL WITH SPRINKLER SYSTEM ALLOWED: 75'-0"  
MAX COMMON PATH OF TRAVEL WITH SPRINKLER SYSTEM PROVIDED: N/A

PER TABLE 1017.2  
MAX EXIT ACCESS TRAVEL DISTANCE ALLOWED: 250'-0"  
MAX EXIT ACCESS TRAVEL DISTANCE ALLOWED: 58'-0 1/4"

EGRESS ANALYSIS LEGEND


TAG	SYMBOL	DESCRIPTION
---		FIRE EXTINGUISHER
XC		EXIT SIGN
EL		EMERGENCY LIGHT (BACK OF HOUSE)
EL		EMERGENCY LIGHT (SALES FLOOR)
---		EGRESS POINT
		PATH OF TRAVEL

KEY NOTES

SYMBOL	NOTES
1	HATCHED AREA DENOTES 36" MIN. PATH OF EGRESS. ACCESSIBLE PATH IS TO BE KEPT CLEAR OF OBSTRUCTIONS AT ALL TIMES.
2	INTERNALLY ILLUMINATED EXIT SIGN. EXIT SIGN TO HAVE A 90 MINUTE BATTERY BACK UP. SEE SCHEDULE FOR ADDITIONAL INFORMATION.
3	EMERGENCY LIGHT TO BE INSTALLED WITH 90 MINUTE BACK UP BATTERY. SEE SCHEDULE FOR ADDITIONAL INFORMATION. COORDINATE EXACT LOCATION WITH ENGINEERING DRAWINGS.
4	THE MEANS OF EGRESS ILLUMINATION LEVEL SHALL NOT BE LESS THAN 1 FOOTCANDLE (11 LUX) AT THE WALKING SURFACE.
5	FIRE EXTINGUISHERS PROVIDED AND INSTALLED BY G.C. G.C. TO COORDINATE EXACT LOCATION AND QUANTITIES WITH THE FIRE MARSHAL IN THE FIELD, AS REQUIRED. SEE FIRE SAFETY DRAWINGS FOR MORE INFORMATION. FINAL LOCATION TO BE REVISED AND APPROVED BY OWNER.
6	---
7	---
8	---
9	---

LIFE SAFETY NOTES

- ALL MODIFICATIONS TO THE FIRE ALARM & FIRE SPRINKLER SYSTEM MUST BE PERFORMED BY THE BUILDING REQUIRED VENDORS. G.C. TO CONTRACT W/ VENDORS DIRECTLY
- FIRE ALARM & FIRE SPRINKLER PERMIT TO BE FILED SEPARATELY. FIRE ALARM & FIRE SPRINKLER DWGS ARE NOT BEING REVIEWED WITH THIS SUBMISSION.

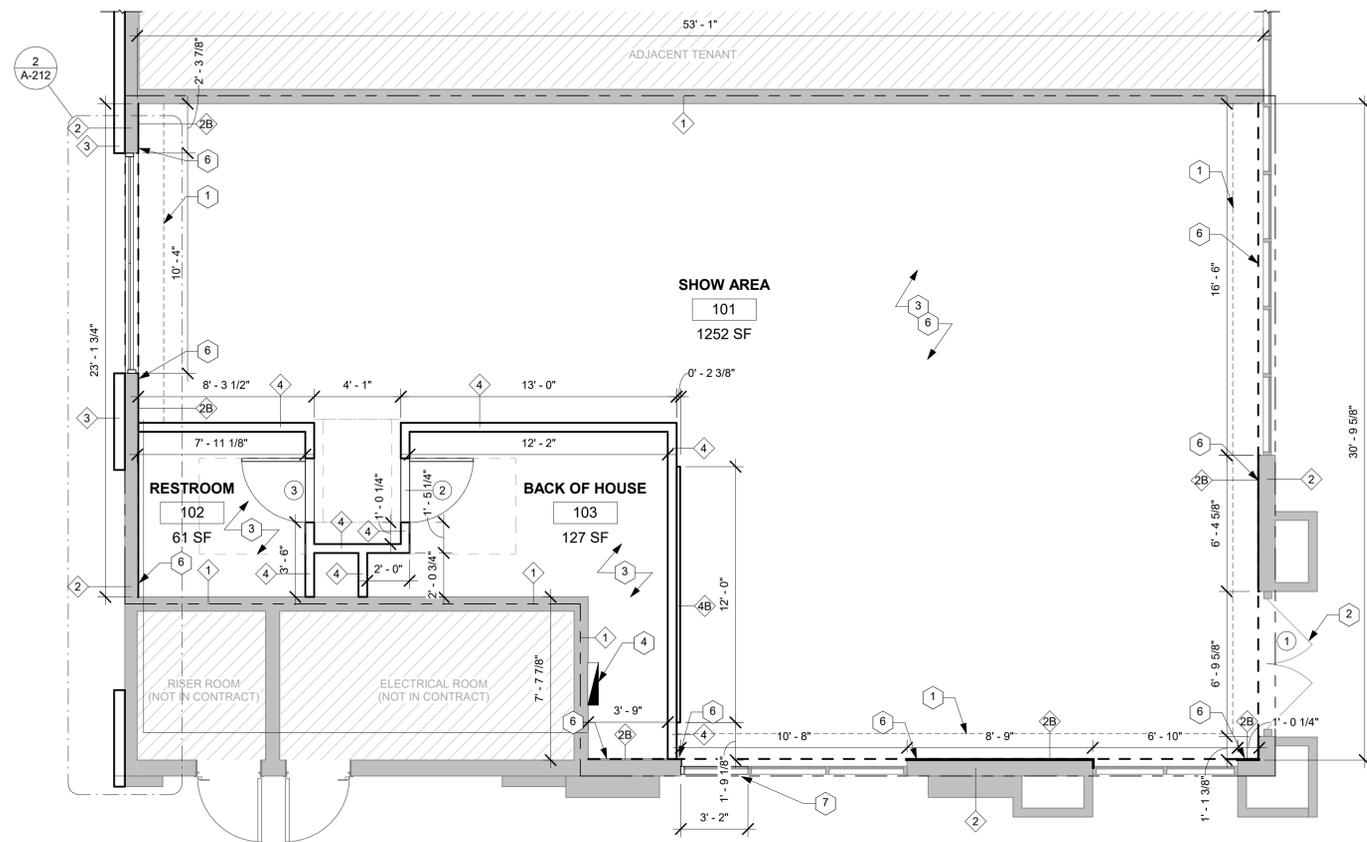

1 CONSTRUCTION PLAN  
1/4" = 1'-0"

**DOOR SCHEDULE**

MARK	DOOR TYPE	THICKNESS	WIDTH	HEIGHT	NEW (N) EXISTING (E)	DOOR MATERIAL	CLEARANCE PUSH   PULL	HARDWARE GROUP	LOCKSET	RATING
1	Glazed Doors & Entrances	0' - 1 3/4"	6' - 1 5/8"	8' - 0"	E	METAL/GLASS	1B/G-104(PUSH) 1F/G-104(PULL)	1		
2	Interior Doors	0' - 1 3/4"	3' - 0"	7' - 0"	N	HOLLOW METAL	1B/G-104(PUSH) 1F/G-104(PULL)	2	PRIVACY	N/A
3	Interior Doors	0' - 1 3/4"	3' - 0"	7' - 0"	N	HOLLOW METAL	1B/G-104(PUSH) 1F/G-104(PULL)	2	PRIVACY	N/A

**HARDWARE GROUP**

**HARDWARE 1:**

KAWNEER 350 STANDARD ENTRANCE. COLOR: DARK BRONZE AA-M10C21A44  
10" CLEAR BOTTOM RAIL.

CUSTOM TSS LOGO METAL DOOR HANDLE

DOOR HARDWARE TO BE SUBMITTED IN STOREFRONT SHOP DRAWINGS FOR TSS REVIEW AND APPROVAL.

**HARDWARE 2:**

HINGE: STANLEY F179  
CLOSERS: NORTON 8501 BF (HANDICAPPED TYPE)  
WALL BUMPERS (WB): GLYNN - JOHNSON 60W  
FLOOR STOP (FS): GLYNN - JOHNSON FB13  
LOCK GUARD: IVES 180  
LEVER: SCHLAGE BROADWAY (BRW-622)  
MATTE BLACK

CLOSER ALWAYS TO BE PLACED ON NON SALES SIDE OF DOOR

RATED DOOR GASKET: LORIENT ES994 (AT FIRE RATED DOORS ONLY)  
PRIVACY LOCKSET.

ALL DOOR HARDWARE INCLUDING HINGES, CLOSERS, ETC. TO BE MATTE BLACK FINISH.

**GENERAL NOTES**

- ALL DOOR LANDINGS & CLEARANCE SHALL BE LEVELED TO HAVE A SLOPE NO GREATER THAN 1:48.
- LANDINGS ON EITHER SIDE OF A DOOR SHALL BE AT THE SAME LEVEL WITH A MAX ELEVATION CHANGE OF 1/2" COMPLIANT WITH DETAIL 4/G-104
- LANDING SIZE AT DOORS IS DETERMINED BY THE REQUIRED ADA CLEARANCES PER THE ICC A117.1-2009 AND THE MINIMUM REQUIRED LANDING SIZE PER 2018 NEVADA BUILDING CODE, WHICHEVER IS THE MORE STRINGENT CODE.
- ALL BLOCKING FOR ALL WALL MOUNTED CABINETS, FIXTURES, ECT. SHALL BE FRT PLYWOOD.G.C. TO COORDINATE ALL BLOCKING LOCATIONS WITH CLIENT AS REQUIRED
- ON SHEET-ROCK WALLS ALL POWER MUST BE CONCEALED IN THE WALL. IF NOT POSSIBLE TO HIDE IN EXISTING WALL, THERE MUST BE ADDED A HAT CHANNEL AND A LAYER OF 5/8" GYP. BD.
- THE G.C. MUST FINISH NEW AND EXISTING GYP. BD. CEILINGS AND BACK OF HOUSE INTERIOR WALLS TO BE LEVEL 4 FINISH, ALL WALLS IN SALES FLOOR TO BE LEVEL 5.

**CONSTRUCTION LEGEND**

SYMBOL	DESCRIPTION
	EXISTING PARTITION
	NEW PARTITION
	EXISTING DOOR
	NEW DOOR

**KEY NOTES**

SYMBOL	NOTES
1	LINE INDICATES NEW SOFFIT ABOVE.
2	EXISTING STOREFRONT SYSTEM AND DOOR TO REMAIN. SEE SHEET A-211 FOR ADDITIONAL INFORMATION.
3	G.C. TO LEVEL EXISTING CONCRETE SLAB IN PREPARATION FOR NEW FLOORING. COORDINATE WITH FLOORING INSTALL INSTRUCTIONS FOR EXACT REQUIREMENTS.
4	NEW ELECTRICAL PANELS FURNISHED AND INSTALLED BY G.C.. SEE ELECTRICAL ENGINEERING DRAWINGS FOR ADDITIONAL INFORMATION
5	ALL HUNG ITEMS (FIXTURES, CEILING, DUCTWORK, ETC.) MUST BE HUNG FROM THE STRUCTURE OR EXISTING ADDED FRAMEWORK ABOVE PROVIDED AS PART OF IT; NOTHING IS TO BE ATTACHED TO THE UNDERSIDE OF THE DECK ABOVE.
6	DASHED LINE INDICATED EXPOSED PLYWOOD TO BE FINISHED WITH 5/8" GYP. BD.
7	G.C. TO FURNISH AND INSTALL NEW STOREFRONT GLAZING TO INFILL DOOR TO MATCH EXISTING.
8	
9	
10	
11	
12	

ARCHITECT OF RECORD:  
MATTHEW REISKIN  
6200 LENOX ROAD  
BETHESDA, MD 20817  
PH: 240-205-0762  
CHANEISKIN@YAHOO.COM

SEAL:  
ARCHITECT: MATTHEW REISKIN, I  
HEREBY CERTIFY THAT THIS  
DRAWING WAS PREPARED BY ME  
OR UNDER MY DIRECT  
SUPERVISION AND THAT I AM A  
DULY REGISTERED/LICENSED  
ARCHITECT UNDER THE LAWS OF  
THE STATE OF CALIFORNIA

CA ARCHITECTURAL REG. No: C30220

11/17/2022	ARCHITECTURAL MODIFICATION PERMIT SUBMITTAL
11/11/2022	LL REVIEW SET



THE  
SHADE  
STORE

PROJECT LOCATION

THE SHADE STORE  
1875 S BASCOM AVE,  
CAMPBELL, CA 95008

SPACE NO. OP2B

AREA:

SHEET TITLE:

CONSTRUCTION PLAN

PROJECT NO. 22-028


SCALE: AS NOTED

DRAWN BY: AM

REVIEWED BY: MR

SHEET NO:

A-121

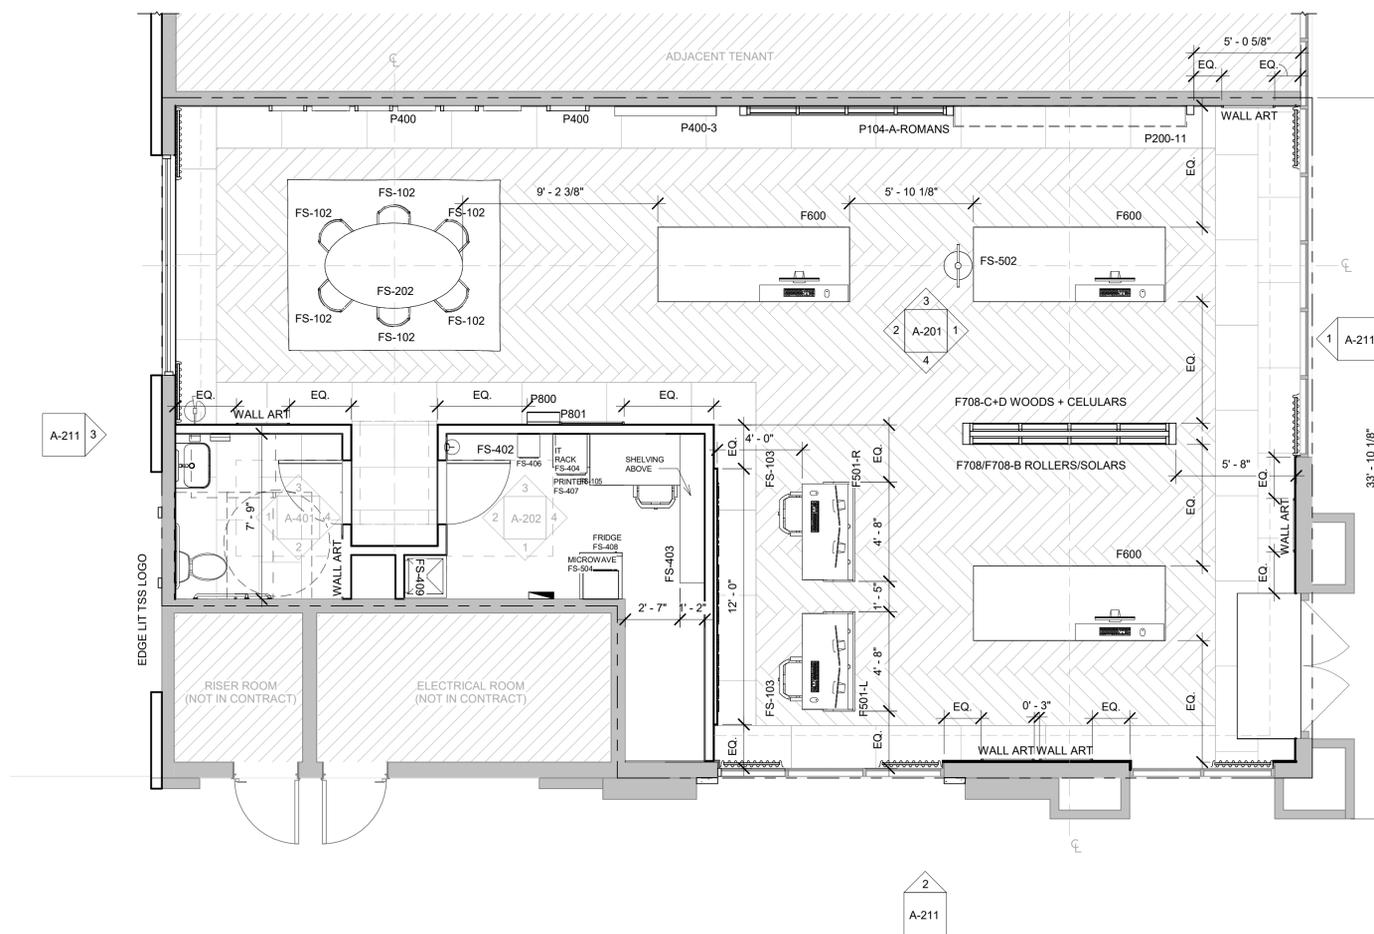

1 FIXTURE PLAN  
1/4" = 1'-0"

FIXTURE SCHEDULE			
TAG #	FIXTURE	QTY.	COMMENTS
F501-L	1 PERSON WORKSTATION	1	SUPPLIED BY MILLWORKER
F501-R	1 PERSON WORKSTATION	1	SUPPLIED BY MILLWORKER
F600	ISLAND	2	SUPPLIED BY MILLWORKER
F600-A	ISLAND	1	SUPPLIED BY MILLWORKER
F708	WOODS + CELLULARS / ROLLERS/SOLARS	1	SUPPLIED BY MILLWORKER
FS-502	FABRIC BOOK UNIT	1	SUPPLIED BY MILLWORKER
P104-A-ROMANS	ROMANS	1	SUPPLIED BY MILLWORKER
P200-11	VALANCE	1	SUPPLIED BY MILLWORKER
P400	HARDWARE OUTSIDE MOUNT	1	SUPPLIED BY MILLWORKER
P400-3	HARDWARE DISPLAY	1	SUPPLIED BY MILLWORKER
P800	PILLOW DISPLAY	1	SUPPLIED BY MILLWORKER
P801	PILLOW DISPLAY GRAPHIC	1	SUPPLIED BY MILLWORKER
	WALL ART	4	SUPPLIED BY OWNER
FS-102	CONFERENCE TABLE CHAIR	6	SUPPLIED BY OWNER
FS-105	DESK AND CHAIR (BOH)	1	SUPPLIED BY OWNER
FS-202	CONFERENCE TABLE	1	SUPPLIED BY OWNER
FS-301	AREA RUG	1	SUPPLIED BY OWNER
FS-402	<varies>	2	SUPPLIED BY OWNER
FS-403	14" SHELVING SYSTEM (BOH)	1	SUPPLIED BY OWNER
FS-404	IT RACK (BOH)	1	SUPPLIED BY OWNER
FS-405	MICROWAVE(BOH)	1	SUPPLIED BY OWNER
FS-406	WATER COOLER	1	SUPPLIED BY OWNER
FS-407	PRINTER (BOH)	1	SUPPLIED BY OWNER
FS-408	REFRIGERATOR (BOH)	1	SUPPLIED BY OWNER
FS-409	UTILITY HOLDER (BOH)	1	SUPPLIED BY OWNER

FIXTURE NOTES	
1.	ALL MILLWORK TO BE FURNISHED AND INSTALLED BY THE MILLWORK CONTRACTOR.
2.	G.C. TO COORDINATE BLOCKING REQUIREMENTS WITH MILLWORK SHOP DRAWINGS PRIOR TO INSTALLATION.
3.	LEVELERS AT BASE OF MILLWORK TO BE SET A LOWEST POSSIBLE SETTING, WHILE ENSURING FIXTURE IS LEVELLED.

ARCHITECT OF RECORD:  
MATTHEW REISKIN  
6200 LENOX ROAD  
BETHESDA, MD 20817  
PH: 240-205-0762  
CHANEISKIN@YAHOO.COM

SEAL:  
ARCHITECT: MATTHEW REISKIN, I  
HEREBY CERTIFY THAT THIS  
DRAWING WAS PREPARED BY ME  
OR UNDER MY DIRECT  
SUPERVISION AND THAT I AM A  
DULY REGISTERED/LICENSED  
ARCHITECT UNDER THE LAWS OF  
THE STATE OF CALIFORNIA

CA ARCHITECTURAL REG. No: C30220

11/17/2022	ARCHITECTURAL MODIFICATION PERMIT SUBMITTAL
11/11/2022	LL REVIEW SET



THE SHADE STORE

PROJECT LOCATION  
THE SHADE STORE  
1875 S BASCOM AVE,  
CAMPBELL, CA 95008

SPACE NO. OP2B

AREA:

SHEET TITLE:

FIXTURE PLAN

PROJECT NO. 22-028

SCALE: AS NOTED


DRAWN BY: RB

REVIEWED BY: MR


SHEET NO:

A-161




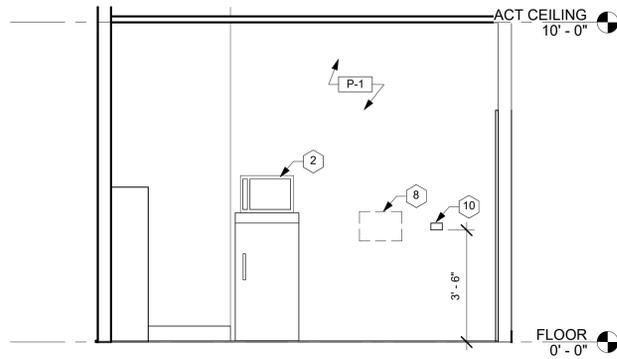


1 BOH ELEVATION 1  
3/8" = 1'-0"

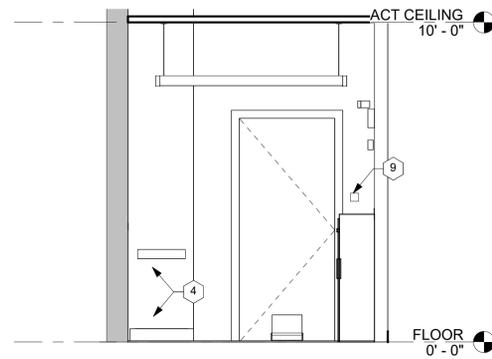

2 BOH ELEVATION 2  
3/8" = 1'-0"

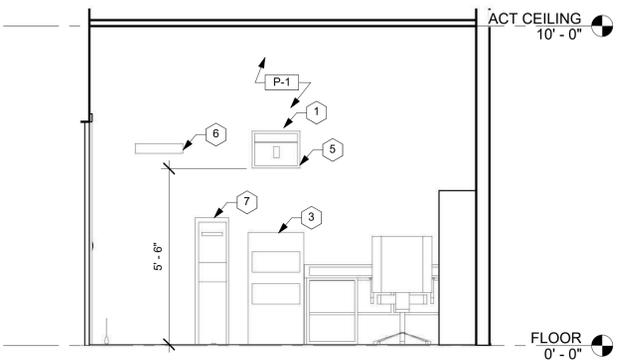

3 BOH ELEVATION 3  
3/8" = 1'-0"

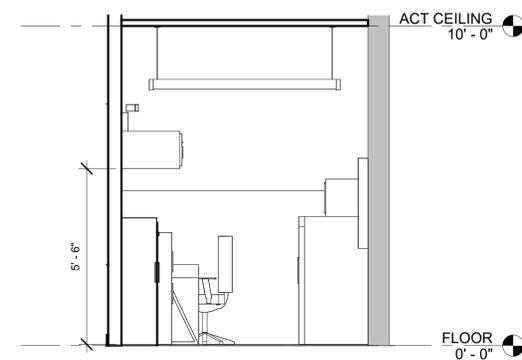

4 BOH ELEVATION 4  
3/8" = 1'-0"

### ELEVATION NOTES

1. ALL BLOCKING TO BE FRT
2. FOR MILLWORK DETAILS SEE SHEETS A-301 THROUGH 311

### KEY NOTES

SYMBOL	NOTES
1	G.C. TO SECURE 3/4" PLYWOOD TO EXISTING WALL FRAMING FOR MOUNTING IT RACK. PLYWOOD TO BE PAINTED TO MATCH WALL.
2	FRIDGE/MICROWAVE
3	PRINTER
4	MOP SINK / UTILITY HOLDER
5	B.O. IT RACK TO BE MOUNTED @6'-0" AFF
6	COATRACK
7	WATER COOLER
8	SWITCH BANK
9	THERMOSTAT
10	DEDICATED OUTLET FOR FIRE ALARM PANEL
11	
12	
13	

ARCHITECT OF RECORD:  
MATTHEW REISKIN  
6200 LENOX ROAD  
BETHESDA, MD 20817  
PH: 240-205-0762  
CHANEISKIN@YAHOO.COM

SEAL:  
ARCHITECT: MATTHEW REISKIN, I  
HEREBY CERTIFY THAT THIS  
DRAWING WAS PREPARED BY ME  
OR UNDER MY DIRECT  
SUPERVISION AND THAT I AM A  
DULY REGISTERED/LICENSED  
ARCHITECT UNDER THE LAWS OF  
THE STATE OF CALIFORNIA

CA ARCHITECTURAL REG. No: C30220

ARCHITECTURAL  
11/17/2022 MODIFICATION  
PERMIT SUBMITTAL  
11/11/2022 LL REVIEW SET



THE  
SHADE  
STORE

PROJECT LOCATION  
THE SHADE STORE  
1875 S BASCOM AVE,  
CAMPBELL, CA 95008

SPACE NO. OP2B

AREA:

SHEET TITLE:

INTERIOR ELEVATIONS

PROJECT NO. 22-028

SCALE: AS NOTED

DRAWN BY: RB


REVIEWED BY: MR

SHEET NO:


A-202






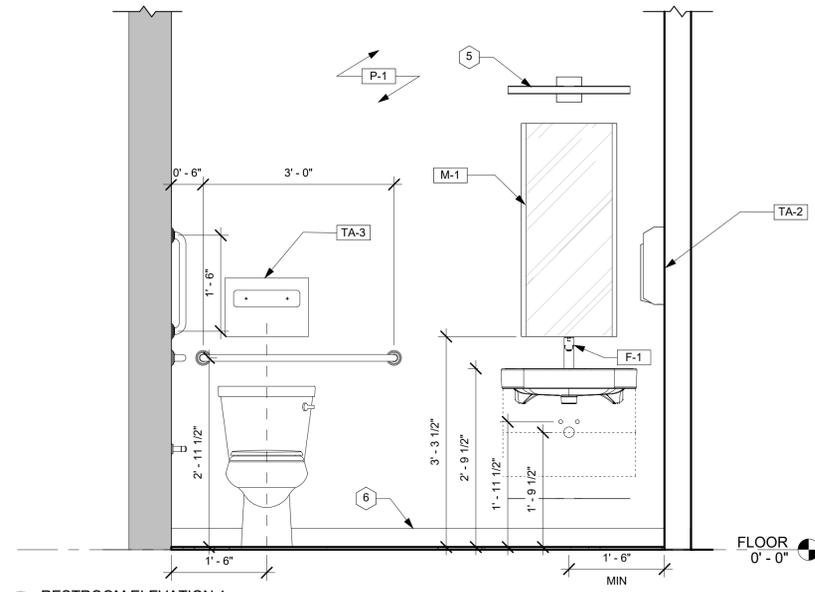


1 RESTROOM ELEVATION 1  
3/4" = 1'-0"

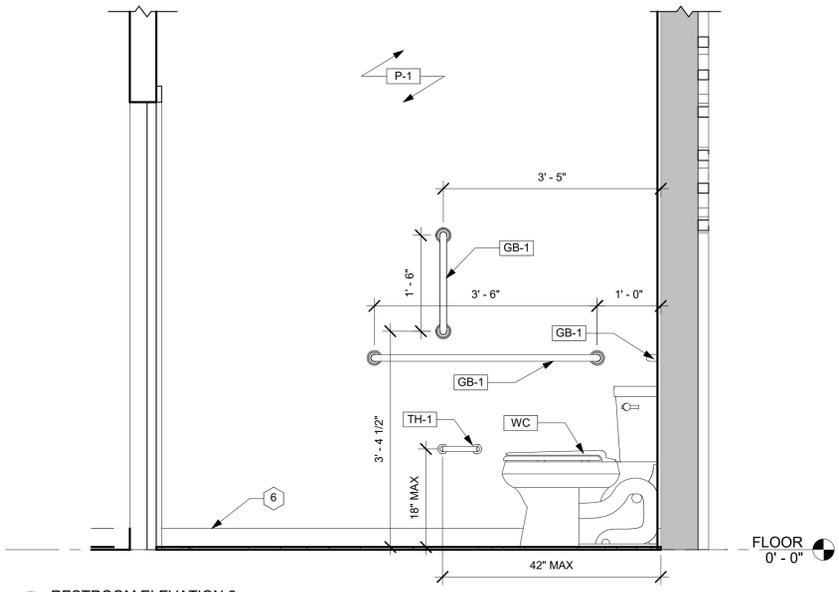


2 RESTROOM ELEVATION 2  
3/4" = 1'-0"

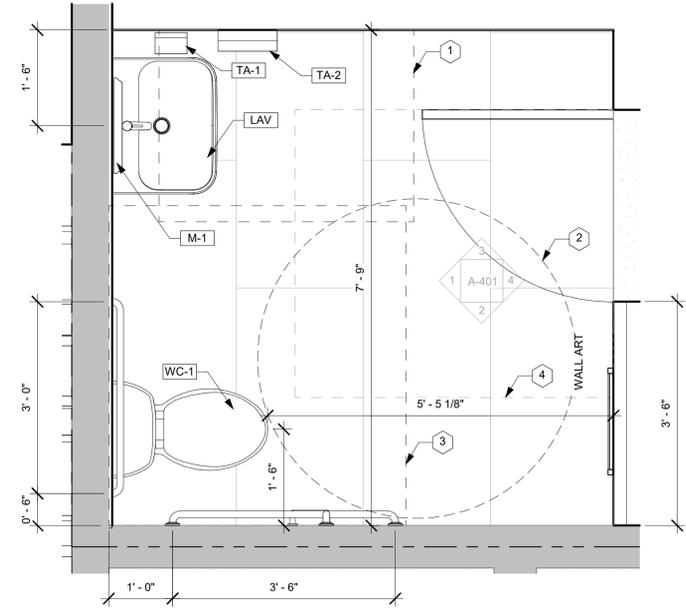

5 ENLARGED RESTROOM PLAN  
3/4" = 1'-0"

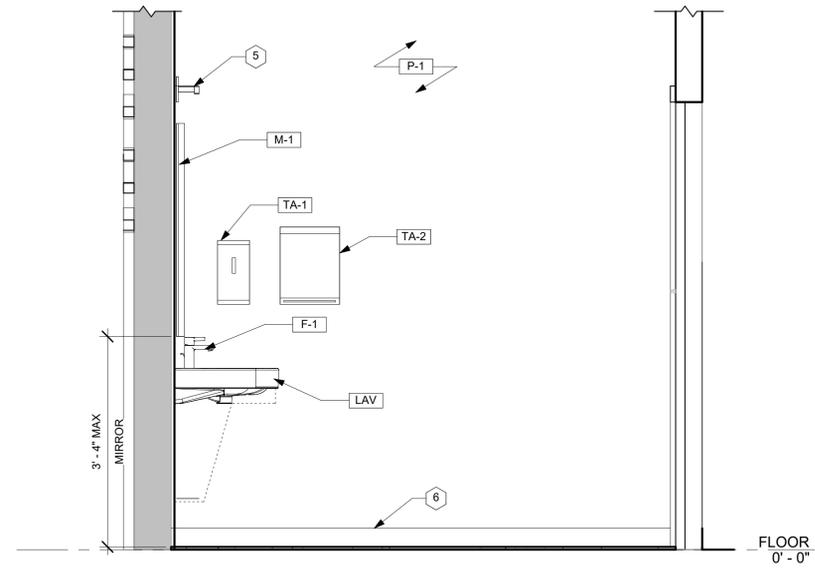

3 RESTROOM ELEVATION 3  
3/4" = 1'-0"

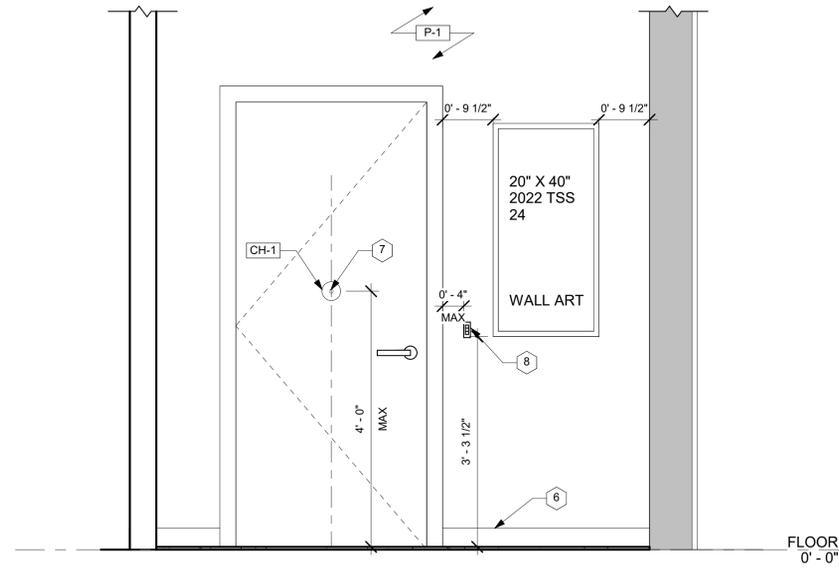

4 RESTROOM ELEVATION 4  
3/4" = 1'-0"

KEY NOTES	
SYMBOL	NOTES
1	30" X 48" CLEARANCE @SINK STARTING @CENTERLINE OF TRAP
2	5'-0" TURNING RADIUS
3	56"X60" CLEARANCE @ ADA WATER CLOSET
4	DOOR CLEARANCE PER SHEET G-104
5	WALL SCNCE - SEE REFLECTED CEILING PLAN FOR ADDITIONAL INFORMATION
6	T-1 TILE BASE. SEE FINISH PLAN FOR ADDITIONAL INFORMATION
7	SURFACE MOUNT HOOK
8	OCCUPANCY SENSOR
9	
10	
11	

GENERAL NOTES	
<ul style="list-style-type: none"> <li>INSULATE WATER SUPPLY AND DRAIN PIPES UNDER LAVATORIES AND SINKS.</li> <li>PIECES OF WALL ART. G.C. TO COORDINATE WITH CLIENT FOR ADDITIONAL INFORMATION.</li> </ul>	

PLUMBING SCHEDULE						
SYMBOL	ITEM	SPEC	VENDOR	PART #	ACCESSORIES	NOTES
WC	ADA FLOOR MOUNTED TOILET	KOHLER HIGHLINE COMFORT HEIGHT TWO PIECE ELONGATED 28 GPD CHAIR HEIGHT TOILET, WHITE, KOHLER WLLWORTH HIGHLINE TOILET TRIP LEVER, MATTE BLACK; KOHLER LUSTRA ELONGATED TOILET SEAT K-4650, WHITE	KOHLER	K-3999-0 OR K-3999-RA-0	TRIP LEVER - K-9379-BL TOILET SEAT - K-4650	G.C. TO SUPPLY
LAV	ADA LAVATORY	DURAVIT HAPPY D WALL MOUNT CERAMIC BATHROOM SINK	SUPPLY.COM	2318650000		G.C. TO SUPPLY
F-1	FAUCET	SINGLE HANDLE BATHROOM FAUCET (BLACK)	DELTA	DELTA #559LF-BLMPU FAUCET WITH SINGLE HANDLE	.5 GPM AERATOR - RP73806	G.C. TO SUPPLY
M-1	MIRROR	FRAME-LESS RECTANGULAR 18"W X 40"H BEVELED MIRROR	LAMPS PLUS	STYLE# P1403		G.C. TO SUPPLY
TH-1	TOILET PAPER HOLDER	KOHLER KUMIN TOILET TISSUE HOLDER, MATTE BLACK	KOHLER	K-24546-BL		G.C. TO SUPPLY
GB-1	ADA GRAB BAR	KOHLER KUMIN ADA GRAB BAR, MATTE BLACK; LENGTH AS REQUIRED.	KOHLER	K-24549-BL; K-24551-BL; K-22824-BL		G.C. TO SUPPLY
TA-1	SOAP PUMP	COASTWIDE PROFESSIONAL J-SERIES AUTOMATIC HAND SOAP DISPENSER, 1200 ML, BLACK	STAPLES	CWJAS-B-CC		TSS TO SUPPLY G.C. TO INSTALL
TA-2	PAPER TOWEL DISPENSER	ALPINE INDUSTRIES STAINLESS STEEL NICKEL BRUSHED C-FOLD MULTIFOLD PEPER TOWEL DISPENSER	ALPINE INDUSTRIES	480-AN		G.C. TO SUPPLY G.C. TO INSTALL
TA-3	TOILET SEAT COVER DISPENSER	ASI 0477-SM-41- MATTE BLACK TOILET SEAT COVER DISPENSER- SURFACE MOUNTED	CHOICEBUILDERS OULUTIONS.COM	SKU: 10-0477-SM-41		G.C. TO SUPPLY G.C. TO INSTALL
CH-1	COAT HOOK	LIBERTY 2-1/32" SINGLE POST WALL HOOK, MATTE BLACK	HOME DEPOT	#B29527C-FB-C		G.C. TO SUPPLY G.C. TO INSTALL

ARCHITECT OF RECORD:  
MATTHEW REISKIN  
6200 LENOX ROAD  
BETHESDA, MD 20817  
PH: 240-205-0762  
CHANEISKIN@YAHOO.COM

SEAL:  
ARCHITECT: MATTHEW REISKIN, I  
HEREBY CERTIFY THAT THIS  
DRAWING WAS PREPARED BY ME  
OR UNDER MY DIRECT  
SUPERVISION AND THAT I AM A  
DULY REGISTERED/LICENSED  
ARCHITECT UNDER THE LAWS OF  
THE STATE OF CALIFORNIA

CA ARCHITECTURAL REG. No: C30220

11/17/2022	ARCHITECTURAL
11/17/2022	MODIFICATION
11/17/2022	PERMIT SUBMITTAL
11/11/2022	LL REVIEW SET



THE  
SHADE  
STORE

PROJECT LOCATION  
THE SHADE STORE  
1875 S BASCOM AVE,  
CAMPBELL, CA 95008

SPACE NO. OP2B  
AREA:  
SHEET TITLE:

ENLARGED RESTROOM  
PLAN AND ELEVATIONS

PROJECT NO. 22-028  
SCALE: AS NOTED  
DRAWN BY: Author  
REVIEWED BY: MR  
SHEET NO:

A-401