






City of Campbell  
70 North First Street  
Campbell, CA 95008-1423

### Project Image

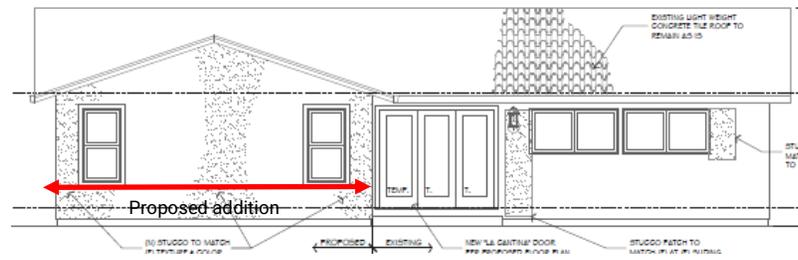

# Courtesy Notice

Dear Campbell Resident,

April 2, 2024

We are notifying you that the Planning Division of the Community Development Department of the City of Campbell has received an application for the following project:

**Project Address:** 1528 Westmont Ave

**Zoning | Area Plan:** R-1-6 | STANP

**Neighborhood Association(s):** Westmont Neighborhood Association

**Council District:** 5

**File No.:** PLN-2024-48

**APN:** 403-13-115

**Applicant:** Aaron Winklebleck, Orchard Home Design

**Property Owner:** Farouk Dey

**Application Type:** Administrative Site and Architectural Review

**Project Planner:** Ishwarya, Planning Technician

**Email Contact:** [ishwarya@campbellca.gov](mailto:ishwarya@campbellca.gov)

**Phone Contact:** (408) 866-2163

**Project Description:**

To allow an approximately 675 square-foot addition to an existing single-story residence and interior remodel.

If you would like to find out more information regarding the proposed project, please view the project plans using the QR code below or contact the Project Planner. The City will send you another notice before the City makes a decision regarding approval of the project.

Before a decision is reached you will receive a formal notice providing another opportunity for public comment.



- City of Campbell -  
Community Development Department  
70 N. First Street, Campbell CA 95008  
(408)866-2140 | [planning@campbellca.gov](mailto:planning@campbellca.gov)

**Note:** Applications may change after initial application submittal. To view the project plans, please scan the QR code.

\*\*Asistencia en Español disponible,  
Simplemente marque (408) 866-2140 y pida traducción en Español




**PROJECT DATA TABLE**

(E) ZONE DESCRIPTION	(E) AREA	(P) ZONE DESCRIPTION	(P) AREA
GROSS LOT SIZE	7139.37		
NET LOT SIZE	4699.34		
EXISTING BUILDING SQ. FT.	2240.40	PROPOSED BUILDING SQ. FT.	2915.40
EXISTING F.A.R.	31.3%	PROPOSED F.A.R.	40.8%
(E) LANDSCAPING SQ. FT.	293.04	(P) LANDSCAPING SQ. FT.	293.04
(E) LANDSCAPING COVERAGE	0.04%	(P) LANDSCAPING COVERAGE	0.04%
(E) PAVED SQ. FT.	1940.45	(P) PAVED SQ. FT.	1842.99
(E) PAVED COVERAGE	27.18%	(P) PAVED COVERAGE	25.81%
(E) IMPERVIOUS SQ. FT.	4180.85	(P) IMPERVIOUS SQ. FT.	4758.99
(E) IMPERVIOUS COVERAGE	58.56%	(P) IMPERVIOUS COVERAGE	66.65%
(E) PERVIOUS SQ. FT.	2958.52	(P) PERVIOUS SQ. FT.	2380.38
(E) PERVIOUS COVERAGE	41.44%	(P) PERVIOUS COVERAGE	33.34%
(E) BUILDING HEIGHT	15'-4 3/4"	(P) BUILDING HEIGHT	15'-4 3/4"
(E) BUILDING SETBACK (F)	20'-0"	(P) BUILDING SETBACK (F)	20'-0"
(E) BUILDING SETBACK (LS)	5'-0"	(P) BUILDING SETBACK (LS)	5'-0"
(E) BUILDING SETBACK (REAR)	5'-0"	(P) BUILDING SETBACK (REAR)	5'-0"
(E) BUILDING SETBACK (RS)	5'-0"	(P) BUILDING SETBACK (RS)	5'-0"
(E) PARKING STALLS	5	(P) PARKING STALLS	5
(E) FIRE SPRINKLER	NO	(P) FIRE SPRINKLER	NO

**LOT COVERAGE CALCULATION**

ZONE	DIMENSIONS	AREA
A	22'-6" x 30'-0"	675.00
B	8'-3" x 34'-1"	623.46
C	11'-3" x 30'-7"	345.21
D	8'-4" x 34'-1"	284.91
E	2'-4" x 34'-1"	422.03
F	3'-4" x 3'-6"	11.91
G	7'-10" x 2'-2"	39.00
H	6'-2" x 2'-2"	13.47
I	23'-11" x 20'-9"	500.41
TOTAL EXISTING (B-I)		2240.40
EXISTING LOT COVERAGE		31.3%
TOTAL PROPOSED (A-I)		2915.40
PROPOSED LOT COVERAGE		40.8%

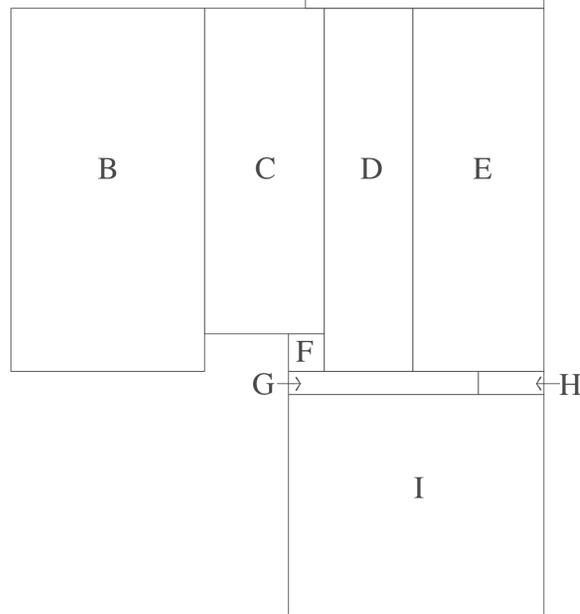

**F.A.R. DIAGRAM 1/8" = 1'-0"**

- CITY OF CAMPBELL NOTES:**
- THE PROJECT SHALL COMPLY WITH THE WASTE MANAGEMENT PLAN (DEFERRED SUBMITTAL)
  - SERVICE PROVIDERS: SAN JOSE WATER COMPANY, PACIFIC GAS AND ELECTRIC (PG&E), WEST VALLEY SANITATION DISTRICT, AND WEST VALLEY COLLECTION AND RECYCLING;
  - NO PRODUCT MAY BE USED THAT EXCEEDS CALIFORNIA'S MAXIMUM LIMITS ON VOLATILE ORGANIC COMPOUNDS (VOC)
  - CONSTRUCTION HOURS ARE LIMITED TO 8 AM TO 5 PM MONDAY THROUGH FRIDAY AND 9 AM TO 4 PM SATURDAY. NO CONSTRUCTION ON SUNDAYS AND HOLIDAYS"

**SHEET INDEX**

SHEET #	DRAWING TITLE
1	COVER SHEET
2	SITE PHOTOGRAPHY SHEET
3	SITE PLAN EXISTING FLOOR PLAN/ DEMOLITION PLAN
4	PROPOSED FLOOR PLAN F.A.R. DIAGRAM
5	ROOF FRAMING PLAN CONSTRUCTION DETAILS
6-7	EXTERIOR ELEVATIONS CONSTRUCTION DETAILS

**SCOPE OF WORK**

 
SINGLE STORY MASTER BEDROOM SUITE ADDITION, # KITCHEN AND BATHROOM REMODEL TO SINGLE FAMILY RESIDENCE.

ALL NEW WINDOWS TO BE "MILGARD" DUAL GLAZED UNITS WITH VINYL FRAME OR EQUAL. ALL NEW WEST FACING WINDOWS SHALL BE LOW'E.

ALL NEW SQUARE SKYLIGHTS SHALL BE: FLAT, TEMPERED, DUAL GLAZE BRONZE ANODIZED ALUMINUM FRAME UNITS AS MANUFAC. BY "VELUX" (OR EQUAL). ALL NEW TUBE SKYLIGHTS SHALL BE "TLR" MODEL "SUN TUNNEL" UNITS AS MANUFAC. BY "VELUX" (OR EQUAL). I.A.M.P.O. #ER-0019.

ALL NEW EXTERIOR TRIM AND FINISH TO MATCH EXISTING.

**WALL LEGEND**




**DEMOLITION NOTES:**

DEMOLITION PLAN IS PROVIDED FOR REFERENCE ONLY. CONTRACTORS SHALL COORDINATE DEMOLITION CAREFULLY WITH FLOOR PLAN AND OTHER SHEETS WHICH INDICATE THE EXTENT AND NATURE OF THE NEW CONSTRUCTION. ANY DISCREPANCIES SHALL IMMEDIATELY BE BROUGHT TO THE ATTENTION OF THE DESIGNER. CONTRACTOR SHALL SECURELY SHORE IN PLACE ALL OVERHEAD STRUCTURES PRIOR TO REMOVING ANY SUPPORTING STRUCTURES

**TECHNICAL INFO**

A.P.N. #	403-13-115
PROJECT ADDRESS	1528 WESTMONT AVENUE
OWNER	FAROUK DEY
EXISTING USE	SINGLE FAMILY RESIDENTIAL
ZONING DESIGNATION	R-1-6
LOT SIZE	7139.37 SQ.FT.
CONSTRUCTION TYPE V-B	
BUILDING OCCUPANCY GROUP	R-3/U
APPLICABLE CODES	2022: CRC, CBC, CMC, CEC, CPC, CAL. ENERGY CODE, # CAL. GREEN BUILDING STANDARDS CODE
(E) RESIDENCE AREA (HEATED)	1633 sq
(P) FIRST FLOOR ADDITIONS (HEATED)	675 sq
(P) SECOND FLOOR ADDITIONS (HEATED)	N/A sq
NEW TOTAL FLOOR AREA	2308 sq
EXISTING GARAGE AREA	607 sq
TOTAL ( HEATED + UNHEATED)	2915 sq

**RESERVED FOR CITY**

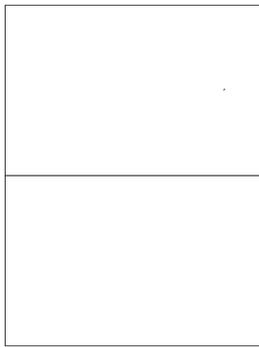

JOB NAME	DEY
JOB NO.	211004
DATE	11/05/21
DRAWN	AW BM
REVISION DATE	BY

ANOTHER SUCCESSFUL PROJECT BY:


**ORCHARD HOME DESIGN**

REMODELING DESIGN PROFESSIONALS, INC.  
WWW.ORCHARDHD.COM (408) 370-3366  
80 GILMAN AVE. #29 CAMPBELL, CALIFORNIA 95008

REMODEL TO:

**THE DEY RESIDENCE**  
1528 WESTMONT AVE  
CAMPBELL, CALIFORNIA 95008  
(352) 573-8230

These drawings, specifications, & sheet format are the property and copyright of Orchard Home Design, Remodeling Design Professionals, Inc. They shall not be used on any work except with the express written consent of the designer. When dimensions shall take precedence over scaled dimensions shall be verified on the job site. Any discrepancies shall be brought to the attention of the designer immediately prior to the commencement or continuance of any work. Questions should be addressed to the offices of Remodeling Design Professionals, Inc. at the location and phone numbers provided on this sheet. Any and all work shall be done in accordance with the drawings and specifications and shall conform to all applicable codes and regulations. Any reproduction of these drawings without the written consent of Orchard Home Design, Remodeling Design Professionals, Inc. is strictly prohibited and constitutes a violation of copyright.

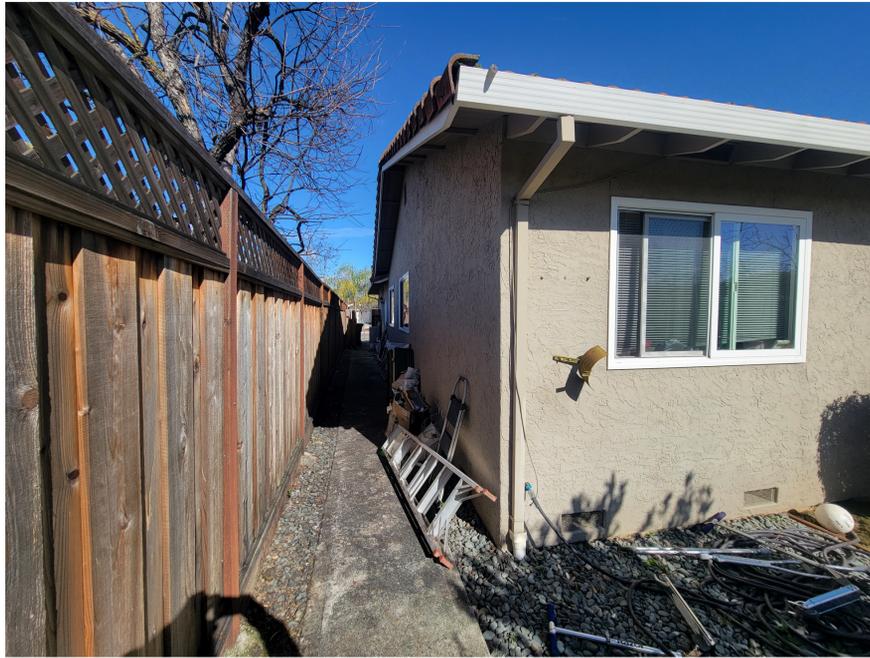

Right Side at Rear



Front Patio



Front



Left Side at Rear



Rear



Rear



JOB NAME DEY  
 JOB NO. 211004  
 DATE 11/05/21  
 DRAWN AW BM  
 REVISION DATE BY

ANOTHER SUCCESSFUL PROJECT BY:  
**ORCHARD** HOME DESIGN  
 REMODELING DESIGN PROFESSIONALS, INC.  
 WWW.ORCHARDHD.COM (408) 370-3366  
 80 GILMAN AVE. #29 CAMPBELL, CALIFORNIA 95008

SITE PHOTOGRAPHY

REMODEL TO:  
**THE DEY RESIDENCE**  
 1528 WESTMONT AVE  
 CAMPBELL, CALIFORNIA 95008  
 (352) 573-8230

SHEET  
**2**  
 OF 7 SHEETS

These drawings, specifications, & sheet format are the property and copyright of Orchard Home Design, Remodeling Design Professionals, Inc. They shall not be used on any work except with the express written consent of the designer. When dimensions are scaled, take precedence over scaled dimensions and shall be verified on the job site. Any discrepancies shall be brought to the attention of the designer immediately. prior to the commencement or continuance of any work. Questions should be addressed to the offices of Remodeling Design Professionals, Inc. at the location and phone numbers included on this sheet. Any use of these drawings, specifications, and/or any other content shall constitute approval by the designer and shall be subject to the terms and conditions of the Standard Design Agreement. Any reproduction of electronic files into alternate formats without the written consent of Orchard Design Professionals, Inc. is prohibited.



**General Notes:**

These general notes have been composed to supplement the information shown elsewhere in plans and specifications, in case of conflict the specific notes or dimensions shown elsewhere in these documents shall govern. In case of a discrepancy in the plans versus what's in the field call the designer immediately, before commencing of that specific work in question.

- All construction shall comply with CRC 2022, CBC 2022, CPC 2022, CMC 2022, CEC 2022 and the 2022 California Energy Code.
- General contractor or owner builder and all subcontractors shall field verify existing conditions and dimensions prior to commencement of work.
- Noted dimensions take precedent over scaled dimensions, any discrepancies shall be immediately brought to the attention of the designer.
- All work shall be performed in conformance with all governing local codes and ordinances.
- Provide 30" clear width, and 24" clear space in front of water closets per C.P.C.
- Bath fans shall provide a min. of 5 air changes per hour. Dampers for fan systems shall comply with title 24. Only low noise units shall be used.
- All water closets shall comply to low flow water requirements. 1.28 gallons of water with air assist systems are required unless noted otherwise.
- Tub /Shower enclosures shall be of an approved shatterproof material per C.R.C. sec. R308.4.
- Glass and glazing per section R308 the C.R.C.
- Provide min 22" x 30" attic access per C.R.C. sec. R807.1: Draft stops per sec. R302.12.
- Egress window openings from sleeping areas shall conform to the req. of C.R.C. sec. R311. Min. net clear width: 20" min. net clr. opng. 5.7 sq. ft.
- Provide approved waterproofing/ flashing at all exterior openings per C.R.C. sec. 703.8.

**Demolition and Removal:**

Demolition plan is provided for reference only (where applicable). Contractor shall coordinate demolition and removal in conjunction with floor plan and other sheets, which indicate the extent and nature of the new construction. Any discrepancies shall immediately be brought to the attention of the designer. Contractor shall securely shore in place all overhead structures prior to removing any supporting structures.

**Clean-up and hauling:**

Contractor shall be responsible for all clean-up and hauling required to complete work as described in these documents. Contractor shall be responsible for the timely removal of debris and un-utilized materials. Upon completion contractor shall leave site clean for occupancy.

**Excavation and Grading:**

Contractors shall clear the site of the proposed structure of any trees or bushes and strip to sufficient depth to remove surface vegetation and weeds. These shall be removed from site. All excavations for foundations shall extend a min. of 12" into firm, un-disturbed native earth (10' in expansive soils) UNO in the soils report/ notes. All forms shall be constructed to remain square, plumb, and level in trenches prior to pouring concrete. All affected areas shall be back filled and compacted prior to completion.

Existing footings or foundations, which may be affected by an excavation, shall be adequately protected against settlement or lateral movement. Soil immediately surrounding building site shall be graded at 5% positively away from foundation for a distance of 10'-0" such that water can not pond adjacent to foundation. Sloping hardscape surfaces shall slope at a gradient of at least 2 percent away from the perimeter of the residence for a distance of at least 8 feet, where possible.

**Concrete and Foundation:**

Foundation shall be constructed in accordance with chapter 4 of the C.R.C.

- Concrete shall develop a minimum compressive strength of 2500 psi at the age of 28 days. (5 sack mix) aggregate size shall be 3/4" max. slump 4-1/2" max. as an alternative 3/8" aggregate "pump-mix" mat be used. (6 sack mix).
- Reinforcing steel shall be intermediate grade deformed bars per A.S.T.M. spec. ASTM A615. Bars shall be clean and free of rust or foreign matter. Lap splices shall be 40" dia. (24" min.) anchor bolts, dowels, holddown anchors, and other required inserts shall be placed so as to develop their full values per manufacturers specs. Minimum concrete coverage for reinforcing steel shall be 3". Reinforcing steel shall be grade 40 reinforcement for #4 and smaller rebars and grade 60 for #5 rebars and larger.
- Provide foundation ventilation equal to 1/150 of the area ventilated per C.R.C. R408.1.
- Provide min. 18" x 24" foundation crawl access per C.R.C. 408.4.
- Provide min. 8" separation between earth and wood at all points along the mudsill.
- Provide plumbing and mechanical access through existing or new foundation as needed. Penetration through foundations to exterior shall be sealed so as to be waterproof.

**Framing:**

Framing shall conform to the provisions of chapters 5, 6 & 8 of the 2022 C.R.C.

- Framing lumber shall be west coast douglas fir larch, or galvanized mt. grade stamped and of a grade approved for its specified use (for wood members). Minimum lumber grades shall be as follows except where noted otherwise: Plates, studs, joists, rafters, door and window headers: #2 and better. (min. lb/ 1450) (psi) beams and posts: #1 (or better (min. lb/ 1750) (psi)
- All members shall be framed, anchored, tied and braced so as to develop the strength and rigidity necessary for the purpose for which they are used.

**Framing Details:**

- Provide solid blocking or rim joist at the ends of all joists and rafters. Midspan Blocking or approved "x" bracing @ 8'-0" shall be used where joists exceed 2x10. Provide double floor joists at parallel partitions.
- Provide double trimmers at sill for openings 8'-0" width and greater. Double top plate shall have 4'-0" min. lap splice in new construction. Provide "SIMPSON ST6236 typ." 36" seismic strap at top plate where new construction joins existing, unless noted otherwise.
- Wood in contact with concrete shall be pressure treated Douglas Fir.
- Nailing shall conform to C.R.C. R505.3.1(2) R602.3, R402.1 and table R804.3. Floor diaphragms as indicated in the drawings are to be glued and nailed with an approved adhesive so as to prevent squeaks. (dap 2000 or equal).
- Framing hardware is specified on an "or equal" basis and any I.C.C. approved brand may be utilized. All hardware shall be installed per manufacturers' specifications/recommendations.
- Cutting, notching, or boring of framing members shall be in accordance to sections R502.8, R602.6 & R802.7.1 of the C.R.C.
- Bolts where specified through wood, shall be drive fit with washers at outs and heads.
- Provide firestops and or draftstops at all concealed draft openings both horizontal and vertical, per C.R.C. 302.12
- Provide Draft Stops at all Plumbing, Mechanical, Electrical, Ect., penetrations at floor and ceiling in accordance to sec. R302.12 of the C.R.C.

**Drywall:**

Interior wall and ceiling coverings shall conform to the provisions of chapter 7 of the C.R.C.

- Waterproof drywall shall be used at tub recesses and shower areas per C.R.C. R406.
- Provide 5/8" type "x" gypsum board at accessible areas under stairs, and at all walls and ceilings between garages and living spaces per C.R.C section R302.6. Contractor shall match existing textures where patching drywall has been required in existing areas, unless noted otherwise.

**Fireplaces and Chimney's:**

- Masonry fireplaces and chimney's shall be constructed and anchored per Chapter 10 of the C.R.C.
- Chimney's shall project a minimum of 2'-0" above any roof area within 10'-0".
- Chimney's which are to be raised, shall be torn down so as to expose a minimum of 2'-0" of existing steel. New steel shall be lap spliced to existing steel and inspected prior to proceeding.

**Roofing:**

Roofing shall be provided and installed in accordance with the provisions of chapter 9 of the C.R.C.

- Contractor shall warranty the roofing portion of the project for a period of two years after the date the final inspection is signed off.
- All roofs shall be sloped for drainage per Chapter 9 of the C.R.C. Flashing shall be 26-gauge g.i. min. except as noted otherwise, and shall conform to the requirements of C.R.C. R903.2
- Skylights shall conform to the requirements of C.R.C. Section R308.6. Skylights and related flashing shall be installed so as to remain weather-tight and shall be considered a portion of the roof warranty purposes.
- Roofing fasteners shall be corrosion resistant in accordance with CRC R905.2.5.

**Electrical:**

Electrical details (if required) shall be provided by the electrical contractor. Electrical work shall be performed in conformance with the governing local codes and ordinances including the current C.E.C. being enforced.

- Provide (1) electrical receptacle per 6'-0" of perimeter wall at each room including doors, glazing and all usable walls 2'-0" or longer.
- Each room shall have at least one overhead light, or one switched receptacle.
- Provide ufer ground stubbed up at new service locations.

**Smoke Detectors:**

Provide 110v hardwired/ battery back-up, inter-connected smoke detectors at all new bedrooms, hallways and at the top of new stairs per C.R.C. R314. Provide carbon monoxide detectors per C.R.C. R315.2

**Plumbing:**

Plumbing shall be provided and installed in conformance with the governing local codes and ordinances including the current C.P.C being enforced.

- Plumbing water supplies shall be of approved copper tubing. Any connection with ferrous metal pipes shall be provided with a dielectric union. Waste or soil lines shall be of an approved plastic except as noted otherwise. Any cast iron shall be hub-less.
- Sprinkler systems shall be broken out as a separate bid item if not specifically described on the plans.
- All vent terminations must be 10' away or 3' above operable skylights.
- All required Plumbing cleanouts greater 20' from access shall be extended to the exterior of building.

**Mechanical:**

Mechanical systems shall be provided and installed in conformance with the governing local codes and ordinances including the current C.M.C. being enforced. Heating shall be provided per section R303 of the C.R.C.

**Insulation:**

Insulation shall comply with the provisions of sections R302.10 of the C.R.C.

- Existing insulation, which is compacted, removed or damaged during construction, shall be replaced or repaired. All insulation shall be installed so as to insure full R-values indicated.
- See "Title 24 Notes" elsewhere in these documents for other pertinent information.

CONTRACTOR NOTE:  
DESIGNER HAS SUPPLEMENTARY INFORMATION AND/OR PHOTOGRAPHS OF THE EXISTING CONDITIONS OF THIS PROJECT. PLEASE CONTACT THE DESIGNER FOR ACCESS TO THIS CONTENT.

SMOKE DETECTOR REQUIREMENT: CRC 314  
PROVIDE SMOKE DETECTION DEVICES AT ALL BEDROOMS, HALLWAYS, AND LANDINGS PER C.R.C. SECTION R314.1. - SEE ELECTRICAL PLAN FOR SMOKE DETECTOR LOCATION.

CARBON MONOXIDE ALARMS: CRC 315  
PROVIDE 1 INSTALL C.O. ALARM OUTSIDE EACH SEPARATE DWELLING UNIT SLEEPING AREA IN THE IMMEDIATE VICINITY OF THE BEDROOM AND ON EVERY LEVEL OF THE DWELLING UNIT, INCLUDING BASEMENTS.

BEDROOM EGRESS WINDOW REQUIREMENT:  
AT LEAST ONE WINDOW PER BEDROOM SHALL COMPLY W/ EGRESS REQ.'S PER C.R.C. R311

MINIMUM 20" NET WINDOW OPENING WIDTH  
MINIMUM 24" NET WINDOW OPENING HEIGHT  
MIN. 5.7 SQ. FT. NET WINDOW OPENING AREA  
44" MAX. WINDOW CLEAR OPENING HT. ABOVE FIN. FLR

DOORWAY ACCESSIBILITY:  
THRESHOLDS AT DOORWAYS SHALL NOT EXCEED 3/4" IN HEIGHT FOR SLIDING DOORS & 1/2" FOR OTHER DOORS. LANDINGS MAY BE UP TO 7 3/4" BELOW TOP OF THRESHOLDS (IE 7" FINISHED FLOOR TO LANDING HEIGHT w/ 3/4" THRESHOLDS PER C.R.C. R311.3.1)

SHOWER ACCESSIBILITY:  
SHOWER PAN SHALL HAVE A MIN. AREA OF 1024 SQ. INCHES AND A MINIMUM CLEAR DIMENSION OF 30" IN ANY SWITCHED RECEPTACLE.  
SHOWER DOORS SHALL MAINTAIN AN OPENING OF NOT LESS THAN A 22" UNOBSTRUCTED FOR EGRESS PER (CPC 408.6)


SEALED GAS APPLIANCE:  
NEW SEALED GAS HEATING APPLIANCE SHALL BE A "SL-S SLMLINE UNIT (ANSI Z21.68-2014) AS MANUFACTURED BY HEAT-N-GLO OR OR OWNER APPROVED EQUAL.

GLASS TEMPERING:  
TEMPERED GLASS SHALL BE PROVIDED AT THE FOLLOWING LOCATIONS PER CRC R308.4.5:  
• SHOWER ENCLOSURES  
• WINDOWS WITHIN 60" HOR. OF A TUB/SHOWER EDGE AND 60" VERT. OF THE STANDING SURFACE  
• WINDOWS WITHIN 18" OF THE FLOOR.  
• ALL GLAZING IN DOORS  
• ALL GLAZING WITHIN THE SWING OF A DOOR.

EXISTING W/IT NOTE:  
EXISTING WATER HEATER TO REMAIN. VERIFY / PROVIDE 18" HIGH PLATFORM PER C.P.C.  
VERIFY / PROVIDE INSULATION BLANKET 4 SEISMIC STRAPS TOP & BOT. AT WATER HEATER TANK PER C.P.C.  
INSULATE FIRST 5' OF HOT WATER LINE  
PRESSURE-TEMPERATURE RELIEF VALVE SHALL BE RUN TO EXTERIOR OR OTHER APPROVED LOC. PER C.P.C.  
LOCATION & PROTECTION OF HOT WATER HEATERS SHALL BE PER C.P.C.

TITLE 24 INFORMATION:

PLAN ORIENTATION AT BOTTOM	SOUTH
NUMBER OF (E) FLOORS	G07
ATTACHED GARAGE SF.	1633
(E) 1st FLOOR SF.	670
(F) 2ND FLOOR SF.	0
(E) FDN TYPE	RAISED
(F) FDN TYP	RAISED
(E) EXT. WALL FRAMING	(2X4)
(F) EXT. WALL FRAMING	2X6
(E) CEILING HEIGHT	8'-0"
(F) WINDOWS	N/A
(E) SKYLIGHTS	N/A
(F) SKYLIGHTS	N/A
(E) SIDING MATERIAL	SIDING @ FRNT, STUCCO
FUEL AT PROPERTY	NATURAL GAS
NEW HEATING SYSTEM?	NO
(E) HEATING SYSTEM	CENTRAL, GAS, A/C
(F) HEATING SYSTEM	N/A
NEW WATER HEATER?	NO
(E) WATER HEATER	40 GAL. TANK, GAS
(F) WATER HEATER	N/A
(E) DUCT LOCATION	N/A

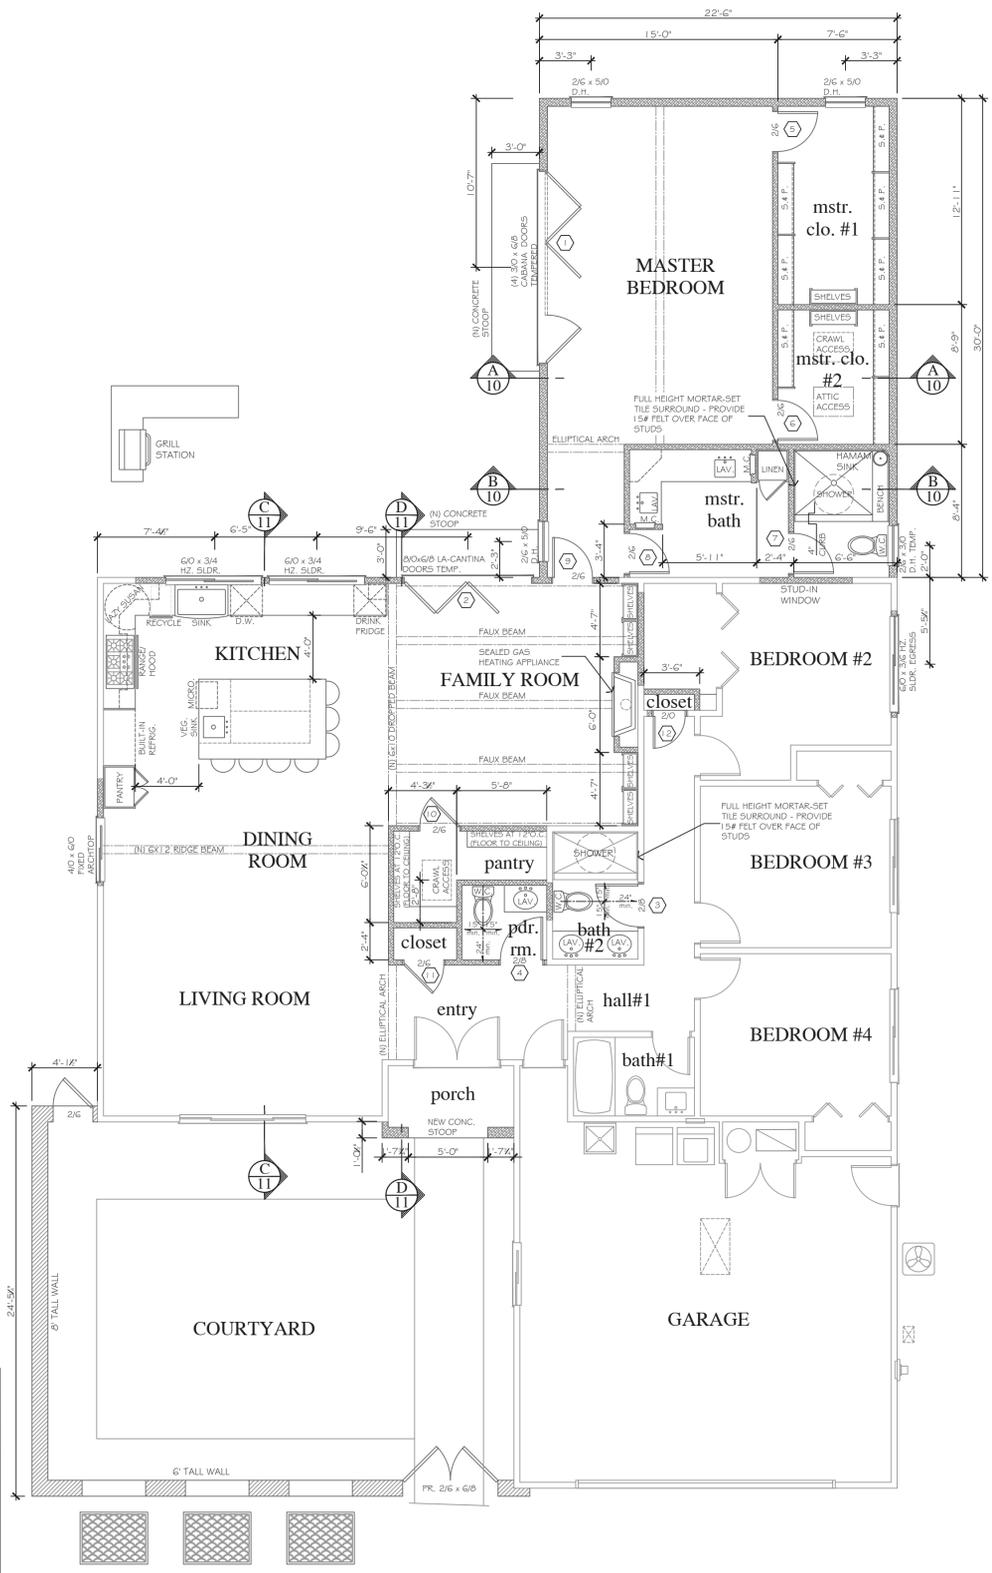

PROPOSED 1st FLOOR PLAN 3/16" = 1'-0"



JOB NAME	DEY
JOB NO.	211004
DATE	11/05/21
DRAWN	AW BM
REVISION DATE	BY

ANOTHER SUCCESSFUL PROJECT BY:

**ORCHARD** HOME DESIGN

REMODELING DESIGN PROFESSIONALS, INC.  
WWW.ORCHARDHD.COM (408) 370-3366  
80 GILMAN AVE. #29 CAMPBELL, CALIFORNIA 95008

PROPOSED 1st FLOOR PLAN  
GENERAL NOTES

REMODEL TO:  
**THE DEY RESIDENCE**  
1528 WESTMONT AVE  
CAMPBELL, CALIFORNIA 95008  
(352) 573-8230

These drawings, specifications, & sheet format are the property and copyright of Orchard Home Design, Remodeling Design Professionals, Inc. They shall not be used on any work except with the express written consent of the designer. Written dimensions shall take precedence over scaled dimensions and shall be verified on the job site. Any discrepancies shall be brought to the attention of the designer immediately prior to the commencement or continuation of any work. Questions should be addressed to the office of Remodeling Design Professionals, Inc. at the location and phone numbers provided on this sheet. An electronic version of these drawings and specifications shall be provided to the contractor upon completion of the project. All electronic versions shall be subject to the same terms and conditions as the printed drawings and specifications. Any transmission of electronic files into alternate formats or modification of electronic files without the express written consent of the designer shall be considered a violation of copyright.




JOB NAME	DEY
JOB NO.	211004
DATE	11/05/21
DRAWN	AW BM
REVISION DATE	BY

ANOTHER SUCCESSFUL PROJECT BY:  
**ORCHARD** HOME DESIGN  
 REMODELING DESIGN PROFESSIONALS, INC.  
 WWW.ORCHARDHD.COM (408) 370-3366  
 80 GILMAN AVE. #29 CAMPBELL, CALIFORNIA 95008

**PROPOSED 1st FLOOR PLAN**


REMODEL TO:  
**THE DEY RESIDENCE**  
 1528 WESTMONT AVE  
 CAMPBELL, CALIFORNIA 95008  
 (352) 573-8230

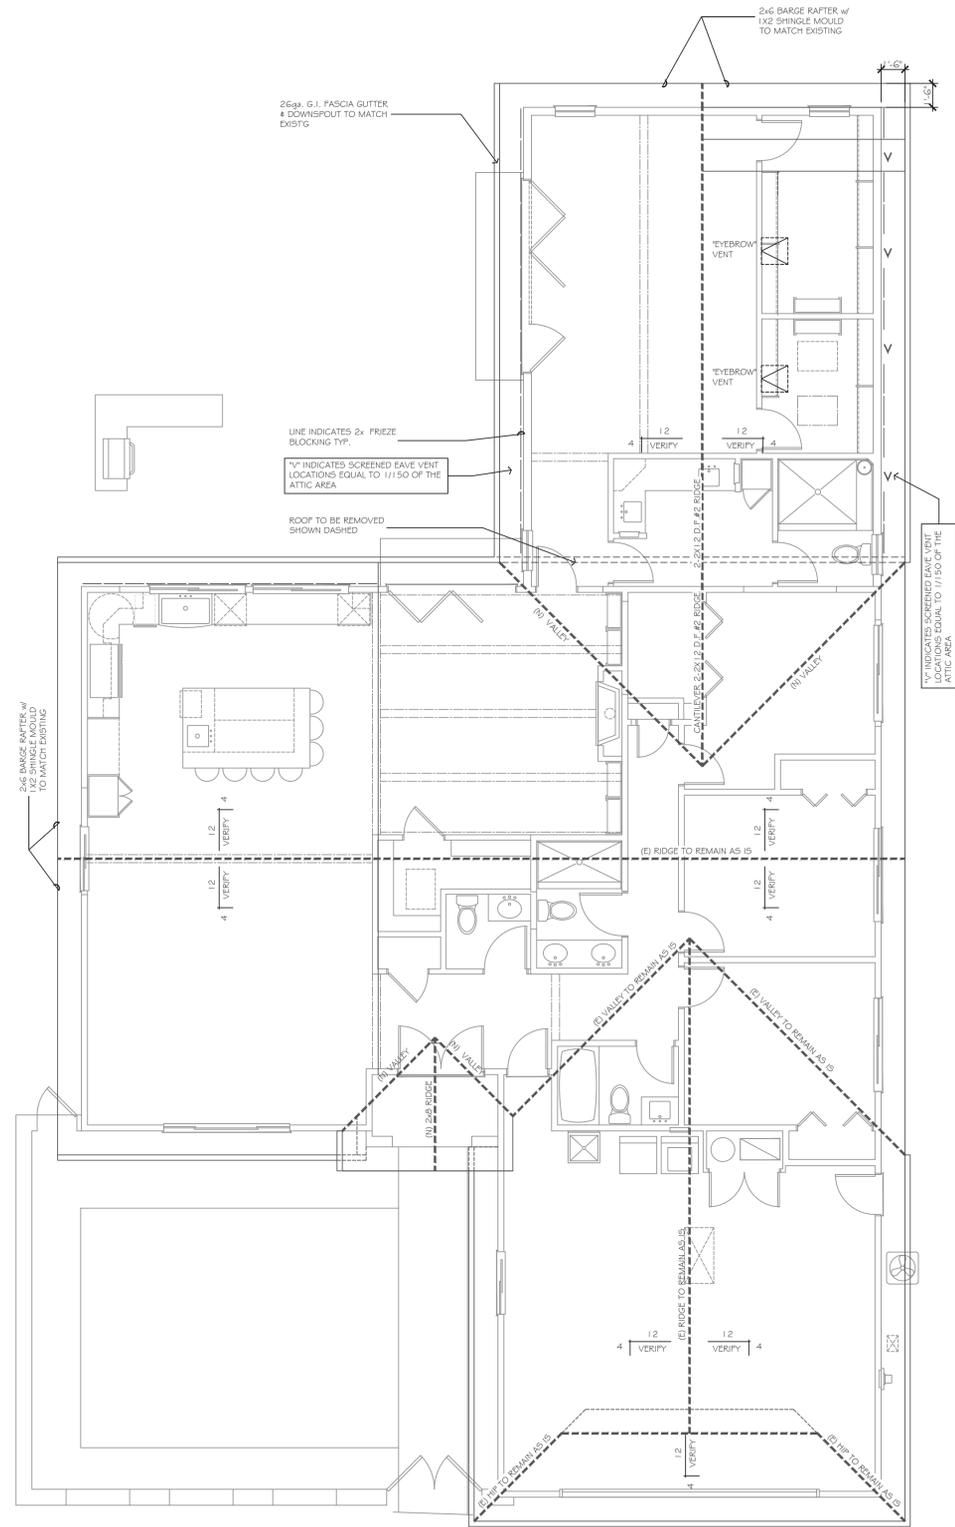


**ROOF PLAN**

3/16" = 1'-0"

These drawings, specifications, & sheet format are the property and copyright of Orchard Home Design, Remodeling Design Professionals, Inc. They shall not be used on any work except with the express written consent of the designer. When dimensions shall take precedence over scaled dimensions and shall be verified on the job site. Any discrepancies shall be brought to the attention of the designer immediately prior to the commencement or continuance of any work. Questions should be addressed to the offices of Remodeling Design Professionals, Inc. at the location and phone numbers indicated on this sheet. Any use, reproduction, or dissemination of any drawings, specifications, or other information without the written approval of the designer is prohibited. All drawings and specifications are the property of Orchard Home Design, Remodeling Design Professionals, Inc. and shall remain the property of the designer. No part of these drawings, specifications, or other information shall be reproduced, stored in a retrieval system, or transmitted in any form or by any means, electronic, mechanical, photocopying, recording, or by any information storage and retrieval system, without the prior written permission of the designer. © Orchard Home Design, Remodeling Design Professionals, Inc. 2021

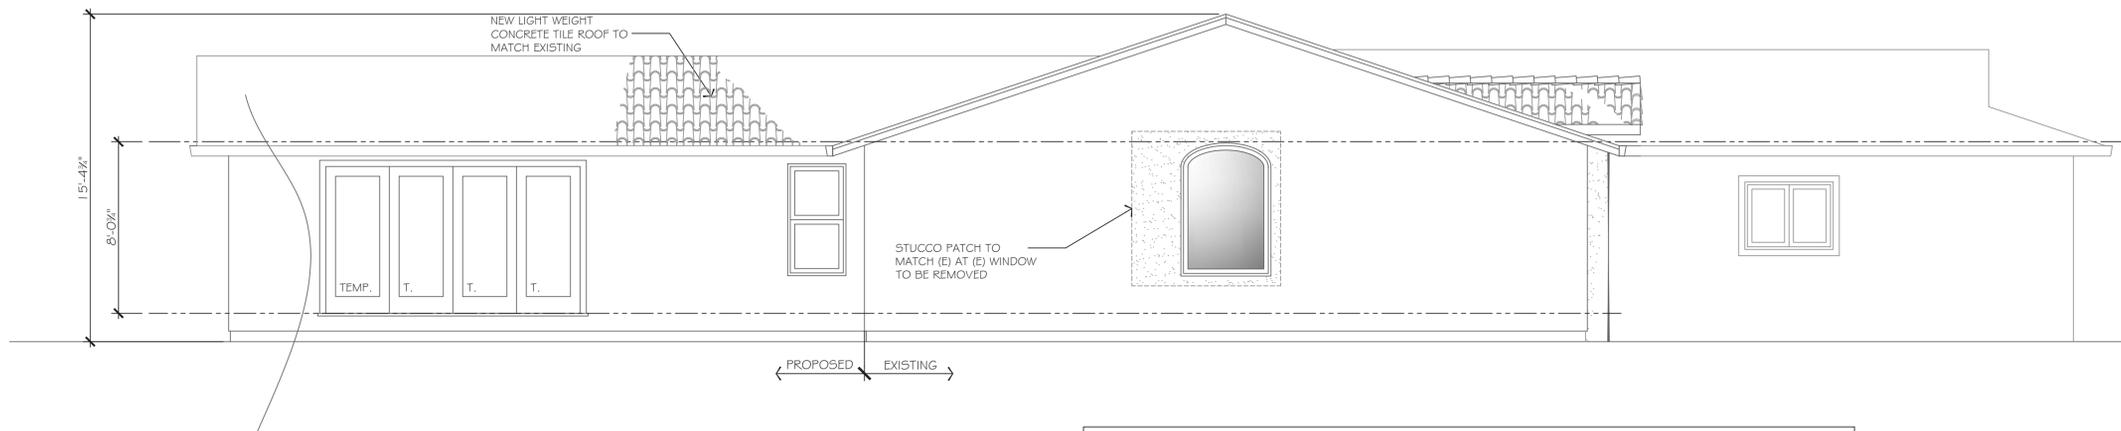

LEFT SIDE ELEVATION 1/4"=1'-0"

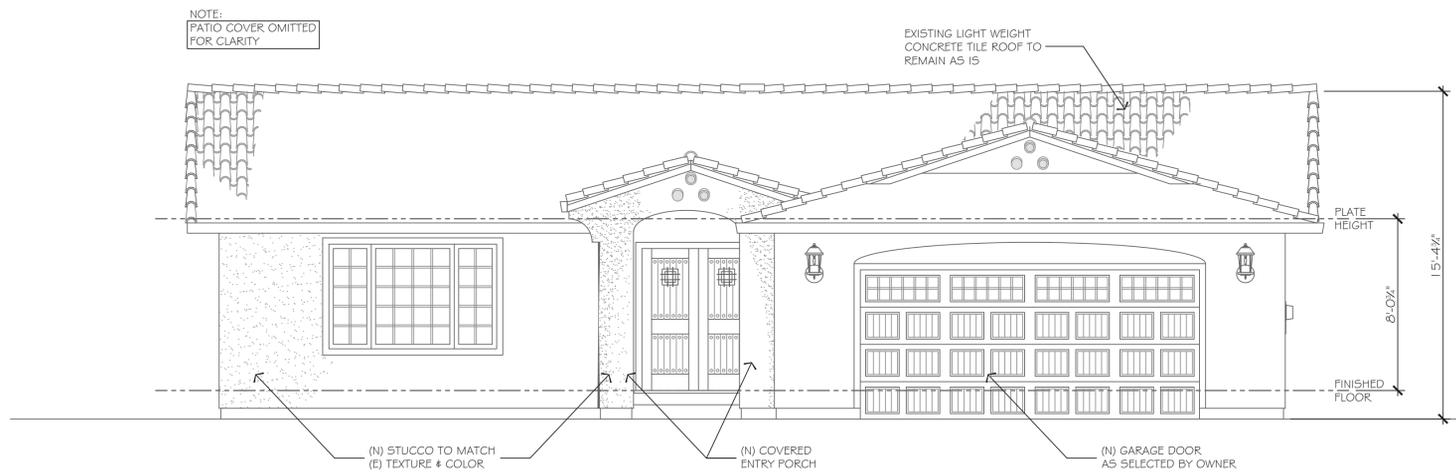

FRONT ELEVATION 1/4"=1'-0"



JOB NAME	DEY
JOB NO.	211004
DATE	11/05/21
DRAWN	AW BM
REVISION DATE	BY

ANOTHER SUCCESSFUL PROJECT BY:  
**ORCHARD** HOME DESIGN  
 REMODELING DESIGN PROFESSIONALS, INC.  
 WWW.ORCHARDHD.COM (408) 370-3366  
 80 GILMAN AVE. #29 CAMPBELL, CALIFORNIA 95008

EXTERIOR ELEVATIONS

REMODEL TO:  
**THE DEY RESIDENCE**  
 1528 WESTMONT AVE  
 CAMPBELL, CALIFORNIA 95008  
 (352) 573-8230

These drawings, specifications, & sheet format are the property and copyright of Orchard Home Design, Remodeling Design Professionals, Inc. They shall not be used on any work except with the express written consent of the designer. When dimensions shall take precedence over scaled dimensions and shall be verified on the job site. Any discrepancies shall be brought to the attention of the designer immediately, prior to the commencement or continuance of any work. Questions should be addressed to the offices of Remodeling Design Professionals, Inc. at the location and phone numbers indicated in the title block. Any use on or any alteration of any drawings, and/or any specifications in this contract is prohibited without the express written consent of RDP, Inc. constitutes a violation of copyright.




JOB NAME	DEY
JOB NO.	211004
DATE	11/05/21
DRAWN	AW BM
REVISION DATE	BY

ANOTHER SUCCESSFUL PROJECT BY:  
**ORCHARD** HOME DESIGN  
 REMODELING DESIGN PROFESSIONALS, INC.  
 WWW.ORCHARDHD.COM (408) 370-3366  
 80 GILMAN AVE. #29 CAMPBELL, CALIFORNIA 95008


**EXTERIOR ELEVATIONS**

REMODEL TO:  
**THE DEY RESIDENCE**  
 1528 WESTMONT AVE  
 CAMPBELL, CALIFORNIA 95008  
 (352) 573-8230

These drawings, specifications, & sheet format are the property and copyright of Orchard Home Design, Remodeling Design Professionals, Inc. They shall not be used on any work except with the express written consent of the designer. Within dimensions shall take precedence over scaled dimensions and shall be verified on the job site. Any discrepancies shall be brought to the attention of the designer immediately prior to the commencement or continuation of any work. Questions should be addressed to the office of Remodeling Design Professionals, Inc. at the location and phone numbers indicated in this block. Any use or reuse of any drawings and/or any specifications in their entirety or in part without the express written consent of Orchard Home Design, Remodeling Design Professionals, Inc. constitutes a violation of copyright.

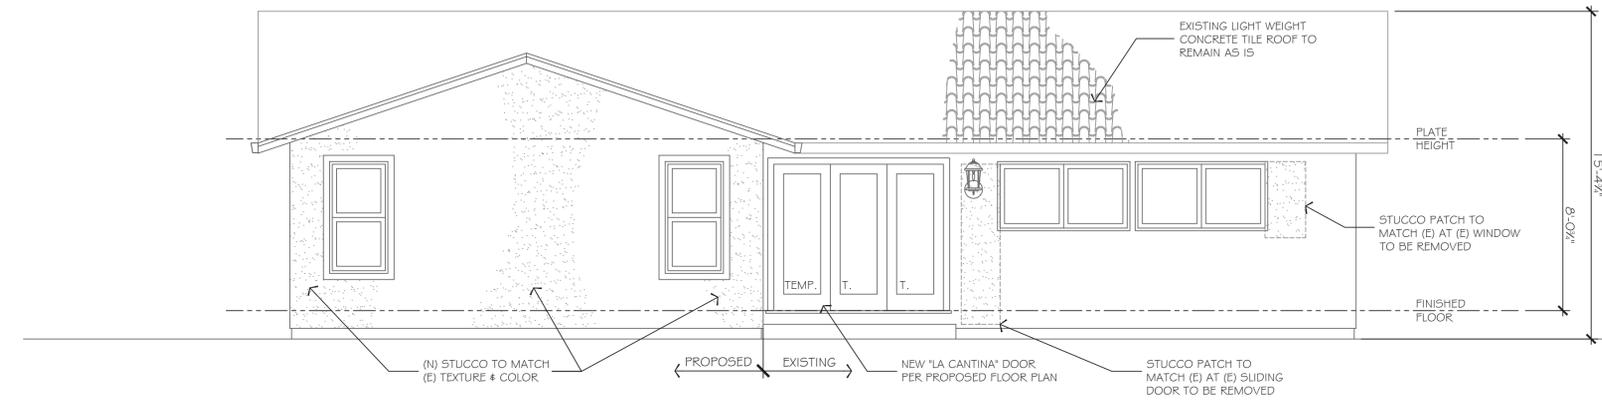

**REAR ELEVATION** 1/4"=1'-0"

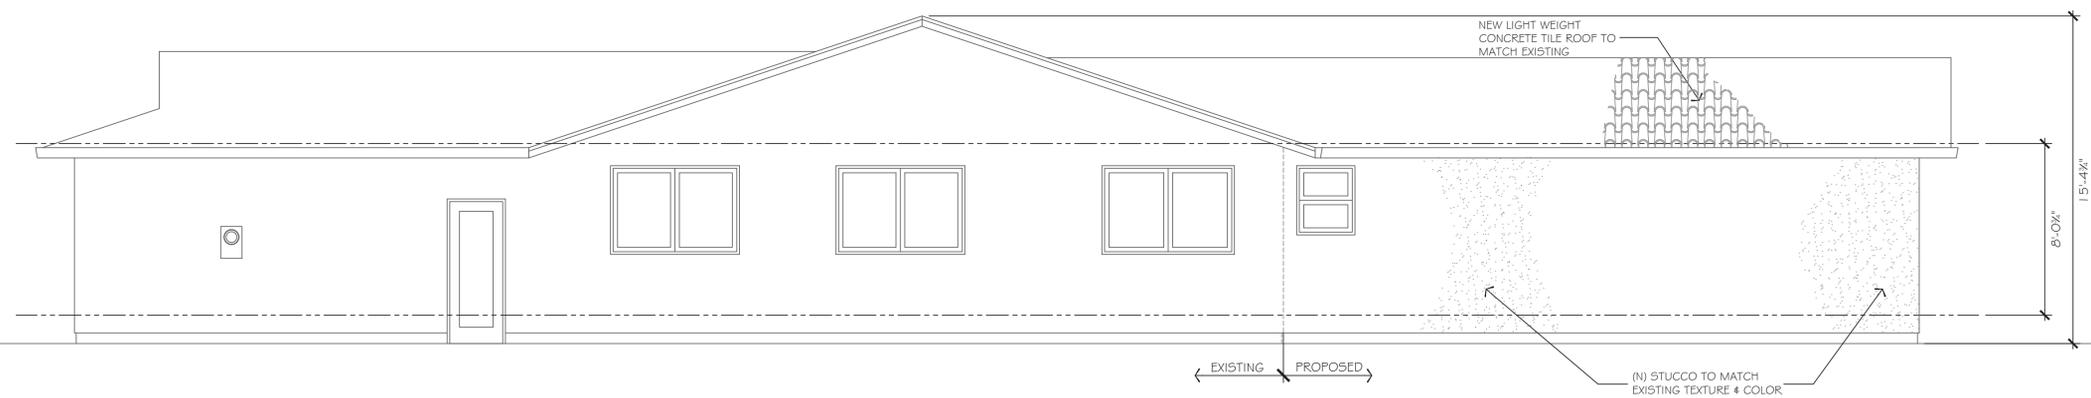

**RIGHT SIDE ELEVATION** 1/4"=1'-0"